



DISH Wireless L.L.C. SITE ID:

SFSFO00580A

DISH Wireless L.L.C. SITE ADDRESS:

**100 FOUNTAIN GROVE PARKWAY
SANTA ROSA, CA 95403**

SCOPE OF WORK
THIS IS NOT AN ALL INCLUSIVE LIST. CONTRACTOR SHALL UTILIZE SPECIFIED EQUIPMENT PART OR ENGINEER APPROVED EQUIVALENT. CONTRACTOR SHALL VERIFY ALL NEEDED EQUIPMENT TO PROVIDE A FUNCTIONAL SITE. THE PROJECT GENERALLY CONSISTS OF THE FOLLOWING:
SECTOR SCOPE OF WORK:
<ul style="list-style-type: none"> • INSTALL (3) PROPOSED FRP SCREEN (1 PER SECTOR) • INSTALL (6) PROPOSED PANEL ANTENNAS (2 PER SECTOR) • INSTALL PROPOSED JUMPERS • INSTALL (12) PROPOSED RRU_s (4 PER SECTOR) • INSTALL (6) PROPOSED OVER VOLTAGE PROTECTION DEVICE (OVP) (2 PER SECTOR) • INSTALL (6) PROPOSED POWER AND FIBER TRUNK
EQUIPMENT SCOPE OF WORK:
<ul style="list-style-type: none"> • INSTALL (1) PROPOSED 9'X8' CHAIN-LINK FENCE • INSTALL (1) PROPOSED 7'X7' CONCRETE PAD WITH H-FRAME • INSTALL (1) PROPOSED CABLE LADDER TRAY OR CABLE TRAY • INSTALL (1) PROPOSED BBU IN CABINET • INSTALL (1) PROPOSED EQUIPMENT CABINET • INSTALL (1) PROPOSED POWER CONDUIT • INSTALL (1) PROPOSED TELCO CONDUIT • INSTALL (1) PROPOSED NEMA 3 TELCO-FIBER BOX • INSTALL (1) PROPOSED GPS UNIT • DIRECT BORING FROM EQUIPMENT AREA TO BUILDING

SITE INFORMATION	PROJECT DIRECTORY
PROPERTY OWNER: VERTICAL BRIDGE REIT, LLC ADDRESS: 750 PARK OF COMMERCE DR. SUITE 200 BOCA RATON, FL 33487	APPLICANT: DISH Wireless L.L.C. 5701 SOUTH SANTA FE DRIVE LITTLETON, CO 80120
COUNTY: SONOMA	SITE DESIGNER: THE CBR GROUP 2840 HOWE ROAD, SUITE E MARTINEZ, CA 94553
LATITUDE (NAD 83): 38.474311	SITE ACQUISITION: PHAN FRONTERA phan@thebrgroup.com
LONGITUDE (NAD 83): -122.727075	CONSTRUCTION MANAGER: JAMES GONZALEZ jim@thebrgroup.com
ZONING JURISDICTION: CITY OF SANTA ROSA	
ZONING DISTRICT: PD 72-001-RC	
PARCEL NUMBER: 173-020-041	
OCCUPANCY GROUP: U	
CONSTRUCTION TYPE: II-B	
POWER COMPANY: PG&E	



5701 SOUTH SANTA FE DRIVE
LITTLETON, CO 80120



2840 HOWE ROAD, SUITE E
MARTINEZ, CA 94553
www.TheCBRGroup.com

CALIFORNIA CODE OF COMPLIANCE								
ALL WORK SHALL BE PERFORMED AND MATERIALS INSTALLED IN ACCORDANCE WITH THE CURRENT EDITIONS OF THE FOLLOWING CODES AS ADOPTED BY THE LOCAL GOVERNING AUTHORITIES. NOTHING IN THESE PLANS IS TO BE CONSTRUED TO PERMIT WORK NOT CONFORMING TO THESE CODES								
<table border="1"> <thead> <tr> <th>CODE TYPE</th> <th>CODE</th> </tr> </thead> <tbody> <tr> <td>BUILDING</td> <td>2019 CALIFORNIA BUILDING CODE (CBC)/2018 IBC</td> </tr> <tr> <td>MECHANICAL</td> <td>2019 CALIFORNIA MECHANICAL CODE (CMC)/2018 UMC</td> </tr> <tr> <td>ELECTRICAL</td> <td>2019 CALIFORNIA ELECTRICAL CODE (CEC)/2020 NEC</td> </tr> </tbody> </table>	CODE TYPE	CODE	BUILDING	2019 CALIFORNIA BUILDING CODE (CBC)/2018 IBC	MECHANICAL	2019 CALIFORNIA MECHANICAL CODE (CMC)/2018 UMC	ELECTRICAL	2019 CALIFORNIA ELECTRICAL CODE (CEC)/2020 NEC
CODE TYPE	CODE							
BUILDING	2019 CALIFORNIA BUILDING CODE (CBC)/2018 IBC							
MECHANICAL	2019 CALIFORNIA MECHANICAL CODE (CMC)/2018 UMC							
ELECTRICAL	2019 CALIFORNIA ELECTRICAL CODE (CEC)/2020 NEC							



DIRECTIONS
DIRECTIONS FROM SAN FRANCISCO INTERNATIONAL AIRPORT:
<ul style="list-style-type: none"> x HEAD NORTHWEST TOWARD US-101 N x FOLLOW US-101 N AND I-80 E TO CA-37 W IN VALLEJO. TAKE EXIT 33 FROM I-80 E x GET ON US-101 N IN PETALUMA x FOLLOW US-101 N TO MENDOCINO AVE IN SANTA ROSA. x TAKE EXIT 492 FROM US-101 N x TURN RIGHT ONTO MENDOCINO AVE


SHEET INDEX	
SHEET NO.	SHEET TITLE
T-1	TITLE SHEET
A-1	OVERALL SITE PLAN
A-2	ENLARGED BUILDING PLAN
A-3	ANTENNA PLAN, RRU PLAN AND SCHEDULE
A-4	EXISTING AND PROPOSED SOUTHWEST ELEVATIONS
A-5	EXISTING AND PROPOSED NORTHWEST ELEVATIONS
A-6	EQUIPMENT PLATFORM AND H-FRAME DETAILS
A-7	EQUIPMENT DETAILS
A-8	EQUIPMENT DETAILS
E-1	ELECTRICAL/FIBER ROUTE PLAN AND NOTES
E-2	ELECTRICAL DETAILS
E-3	ELECTRICAL ONE-LINE, FAULT CALCS & PANEL SCHEDULE
G-1	GROUNDING PLANS AND NOTES
G-2	GROUNDING DETAILS
G-3	GROUNDING DETAILS
RF-1	RF CABLE COLOR CODE
GN-1	LEGEND AND ABBREVIATIONS
GN-2	GENERAL NOTES
GN-3	GENERAL NOTES
GN-4	GENERAL NOTES

UNDERGROUND SERVICE ALERT
UTILITY NOTIFICATION CENTER OF CALIFORNIA
(800) 642-2444
WWW.CALIFORNIA811.ORG
CALL 2-14 WORKING DAYS UTILITY NOTIFICATION PRIOR TO CONSTRUCTION

GENERAL NOTES
THE FACILITY IS UNMANNED AND NOT FOR HUMAN HABITATION. A TECHNICIAN WILL VISIT THE SITE AS REQUIRED FOR ROUTINE MAINTENANCE. THE PROJECT WILL NOT RESULT IN ANY SIGNIFICANT DISTURBANCE OR EFFECT ON DRAINAGE, NO SANITARY SEWER SERVICE, POTABLE WATER, OR TRASH DISPOSAL IS REQUIRED AND NO COMMERCIAL SIGNAGE IS PROPOSED.

11"x17" PLOT WILL BE HALF SCALE UNLESS OTHERWISE NOTED

CONTRACTOR SHALL VERIFY ALL PLANS, EXISTING DIMENSIONS, AND CONDITIONS ON THE JOB SITE, AND SHALL IMMEDIATELY NOTIFY THE ENGINEER IN WRITING OF ANY DISCREPANCIES BEFORE PROCEEDING WITH THE WORK.

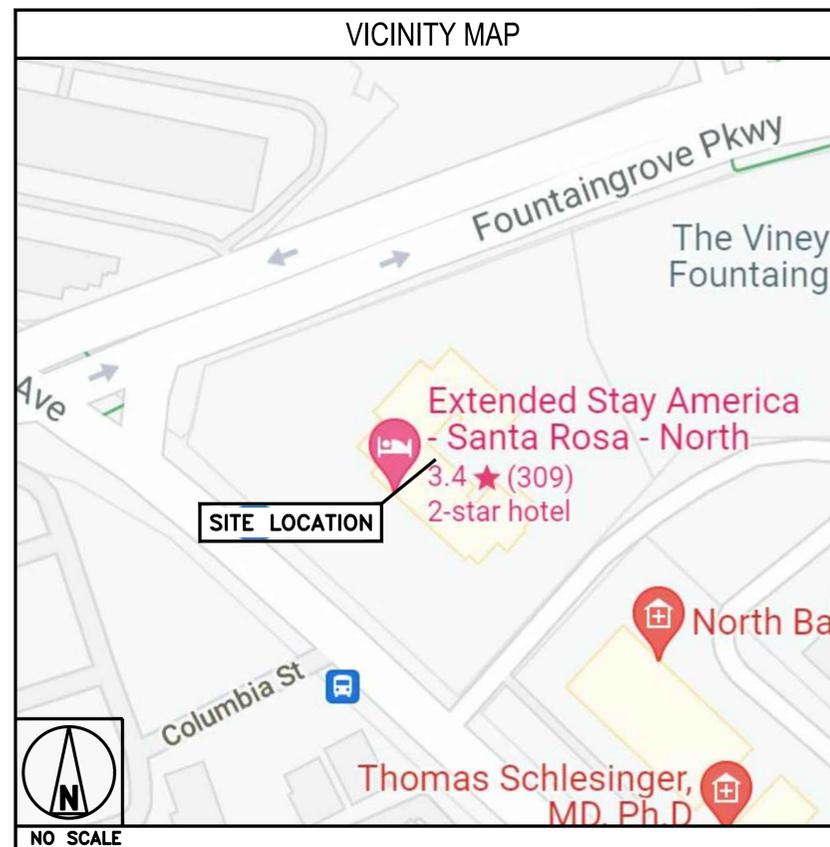

IT IS A VIOLATION OF LAW FOR ANY PERSON, UNLESS THEY ARE ACTING UNDER THE DIRECTION OF A LICENSED PROFESSIONAL ENGINEER, TO ALTER THIS DOCUMENT.

DRAWN BY: MST	CHECKED BY: ---	APPROVED BY: ---
RFDS REV #: 2		02/09/2022

CONSTRUCTION DOCUMENTS


SUBMITTALS		
REV	DATE	DESCRIPTION
A	06/14/2022	90% CD'S ISSUED FOR REVIEW

A&E PROJECT NUMBER
SFSFO00580A

DISH Wireless L.L.C.
PROJECT INFORMATION

SFSFO00580A
100 FOUNTAIN GROVE PKWY
SANTA ROSA, CA 95403

SHEET TITLE TITLE SHEET
SHEET NUMBER T-1

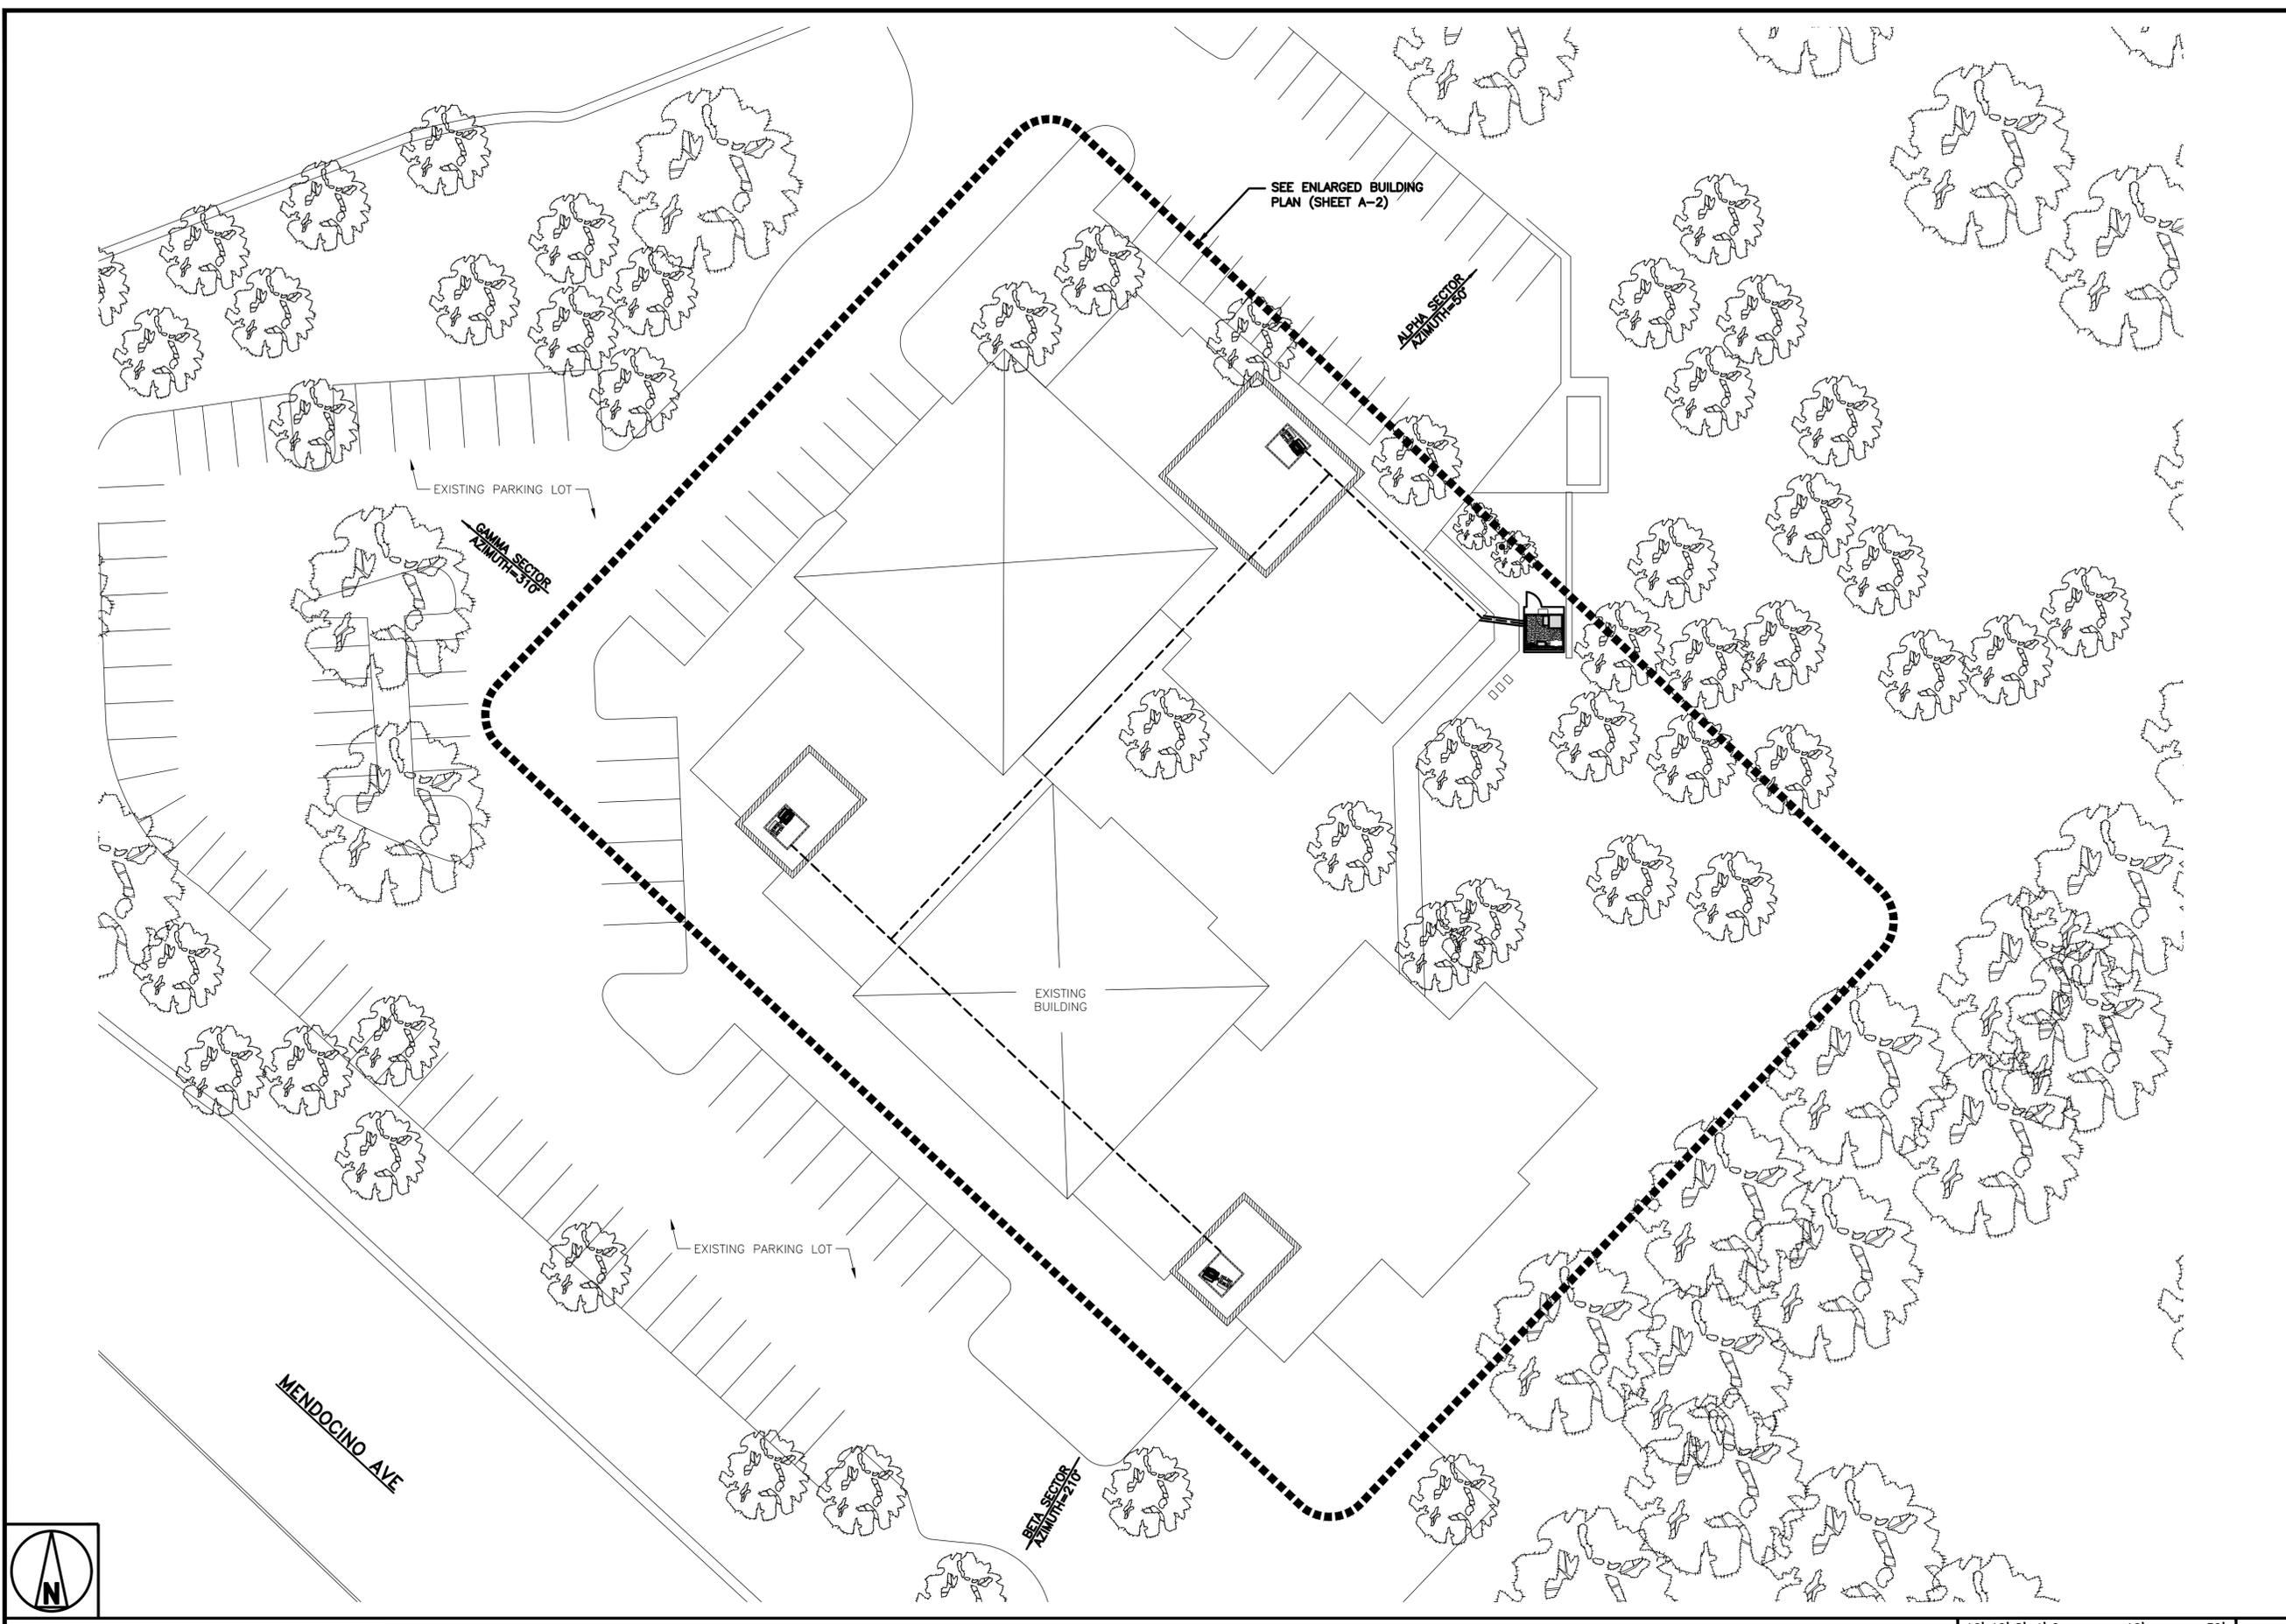

dish
wireless.

5701 SOUTH SANTA FE DRIVE
LITTLETON, CO 80120



2840 HOWE ROAD, SUITE E
MARTINEZ, CA 94553
www.TheCBRGroup.com

IT IS A VIOLATION OF LAW FOR ANY PERSON, UNLESS THEY ARE ACTING UNDER THE DIRECTION OF A LICENSED PROFESSIONAL ENGINEER, TO ALTER THIS DOCUMENT.

DRAWN BY: CHECKED BY: APPROVED BY:
MST --- ---

RFDS REV #: 2 02/09/2022

CONSTRUCTION DOCUMENTS

SUBMITTALS		
REV	DATE	DESCRIPTION
A	06/14/2022	90% CD'S ISSUED FOR REVIEW

 
A&E PROJECT NUMBER
SFSF000580A

DISH Wireless L.L.C.
PROJECT INFORMATION
SFSF000580A
100 FOUNTAIN GROVE PKWY
SANTA ROSA, CA 95403

SHEET TITLE
OVERALL
SITE PLAN

SHEET NUMBER
A-1

OVERALL SITE PLAN



IT IS A VIOLATION OF LAW FOR ANY PERSON, UNLESS THEY ARE ACTING UNDER THE DIRECTION OF A LICENSED PROFESSIONAL ENGINEER, TO ALTER THIS DOCUMENT.

DRAWN BY: CHECKED BY: APPROVED BY:
MST --- ---

RFDS REV #: 2 02/09/2022

CONSTRUCTION DOCUMENTS




SUBMITTALS		
REV	DATE	DESCRIPTION
A	06/14/2022	90% CD'S ISSUED FOR REVIEW

A&E PROJECT NUMBER
SFSF000580A


DISH Wireless L.L.C.
PROJECT INFORMATION
SFSF000580A
100 FOUNTAIN GROVE PKWY
SANTA ROSA, CA 95403

SHEET TITLE
ENLARGED BUILDING PLAN

  SHEET NUMBER
A-2

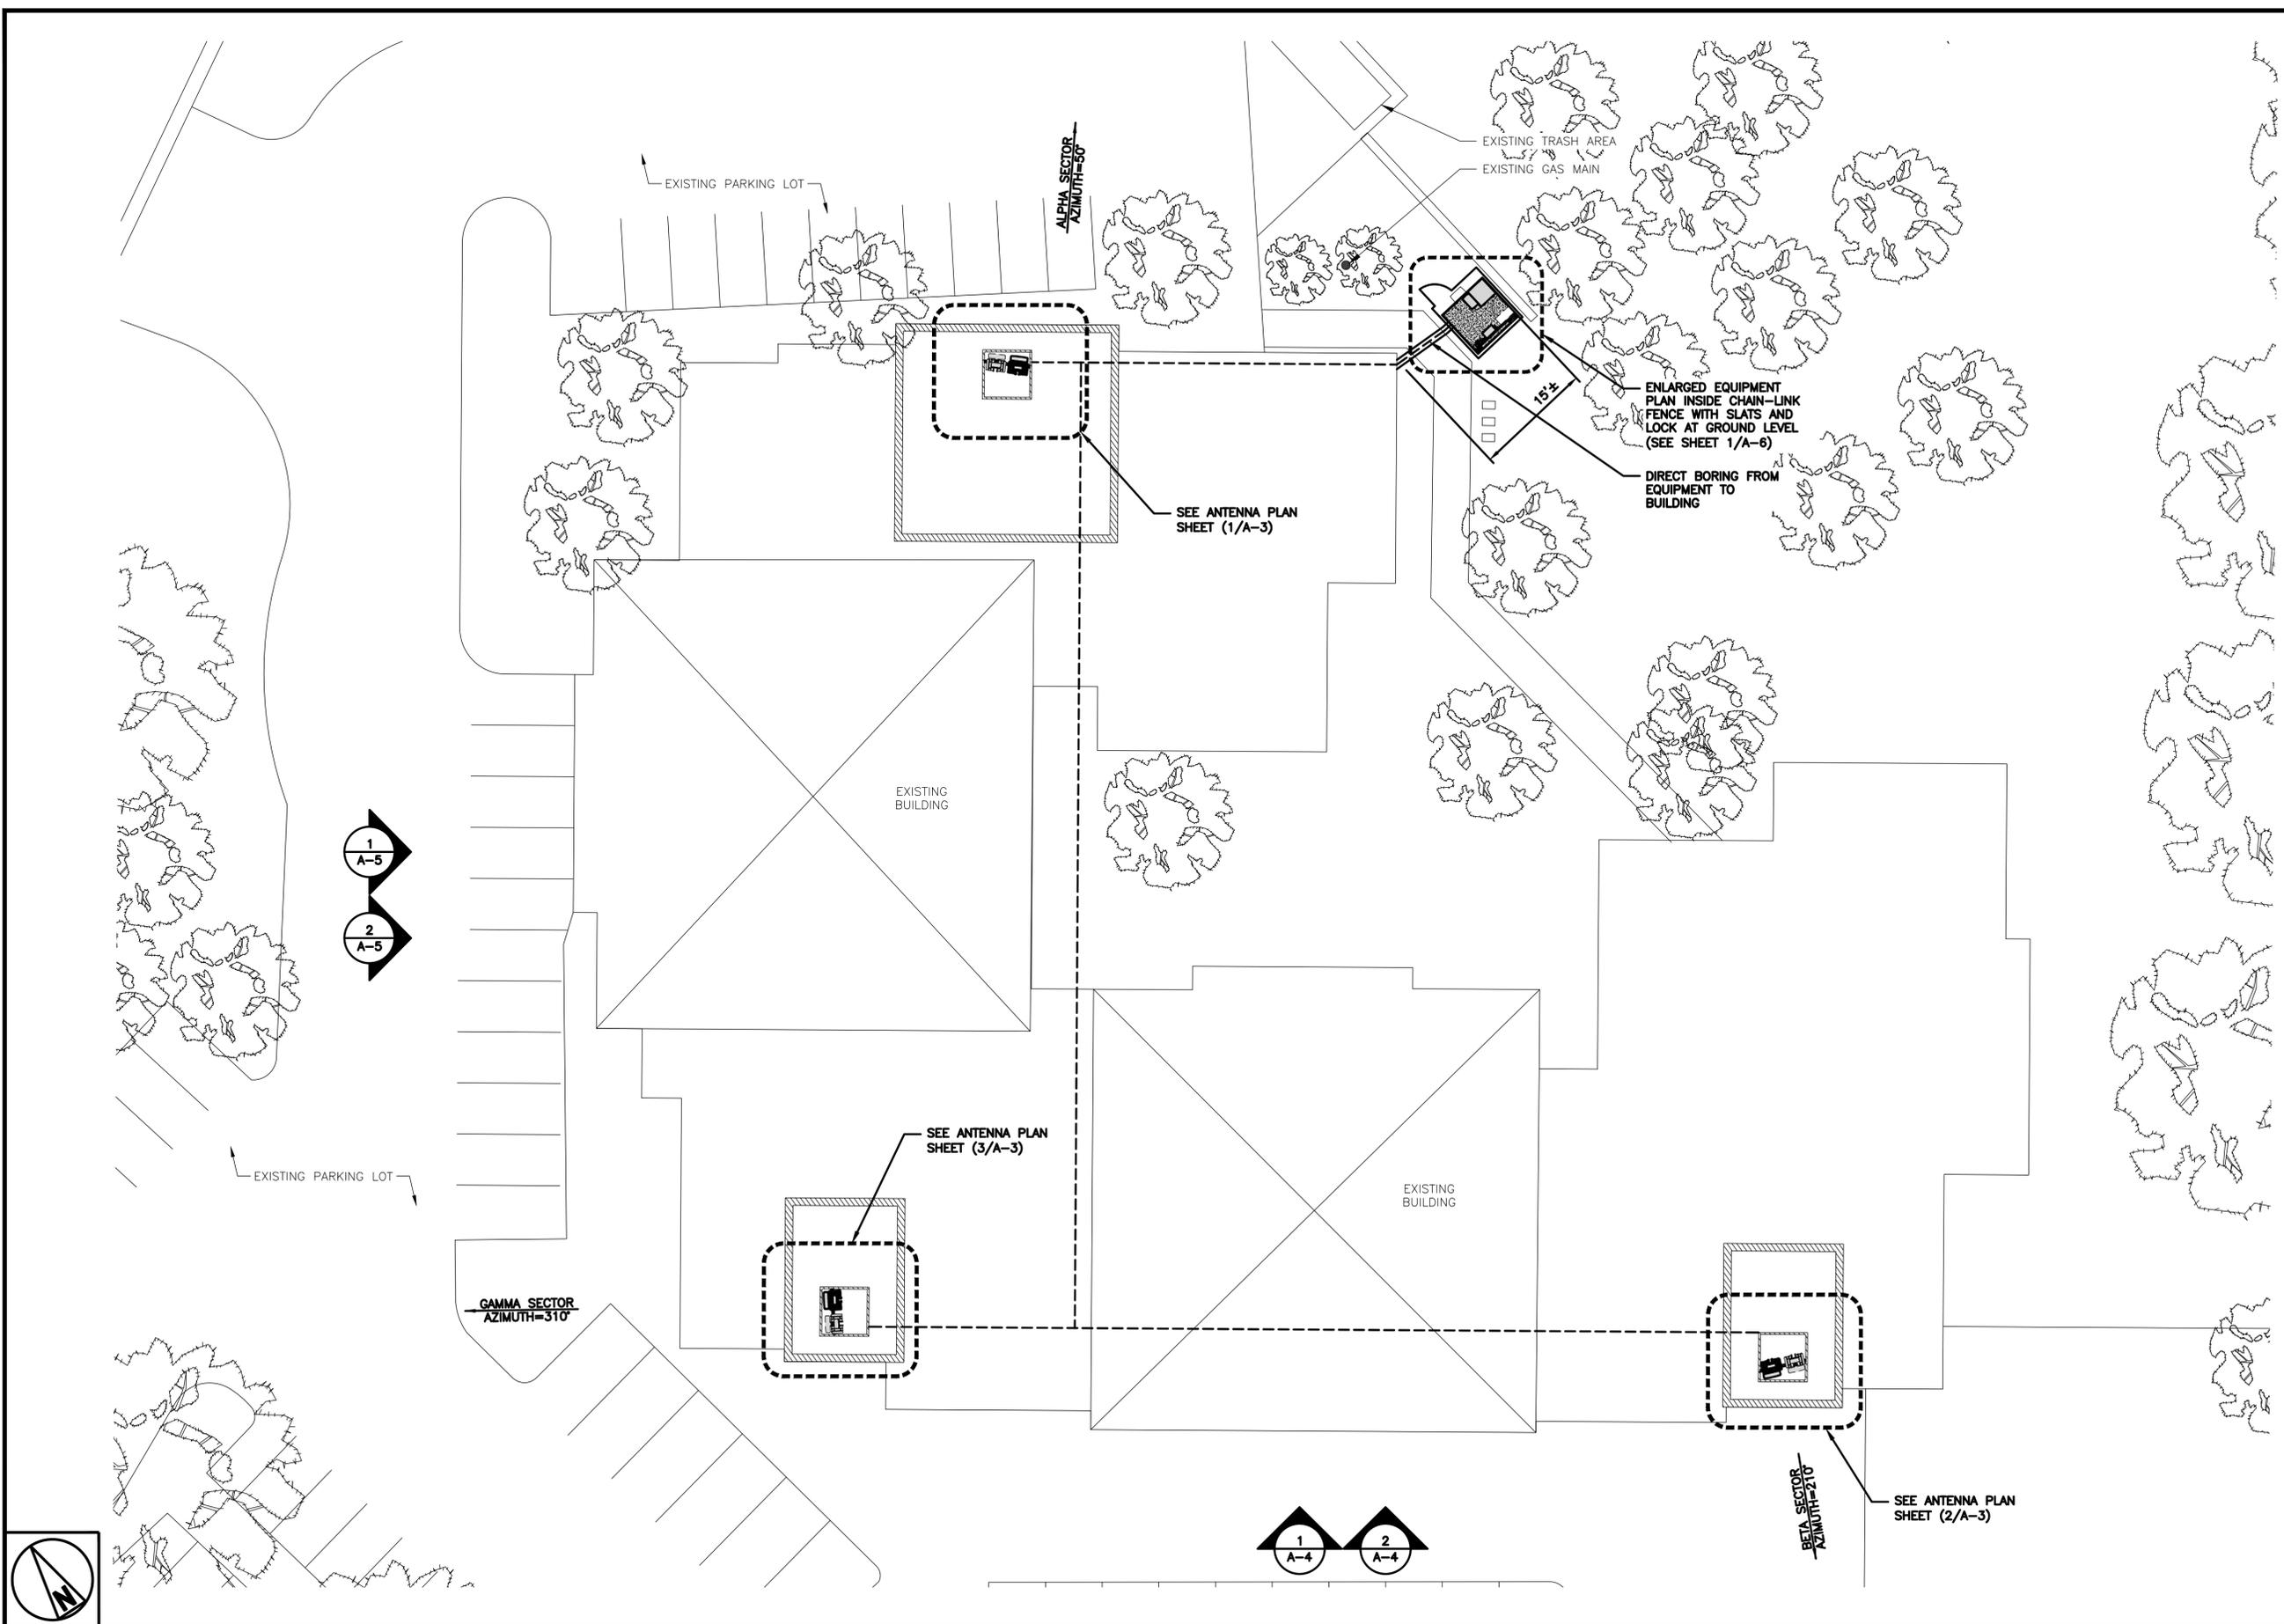


ENLARGED BUILDING PLAN

 


NOTES


1. CONTRACTOR SHALL FIELD VERIFY ALL DIMENSIONS.
2. ANTENNA AND MW DISH SPECIFICATIONS REFER TO A ANTENNA SCHEDULE AND TO FINAL CONSTRUCTION RFDS FOR ALL RF DETAILS
3. ALL NEW EQUIPMENT TO BE PAINTED AND TEXTURED TO MATCH EXISTING BUILDING.
4. EXISTING FINISHES TO BE REPAIRED SO TEXTURE AND COLOR MATCH THE ADJACENT SURFACES.
5. ALL EXPOSED VERTICAL CABLE RUNS SHALL RECEIVE A 22 GAUGE METAL COVER PAINTED TO MATCH THE ADJACENT VERTICAL SURFACE MATERIAL.

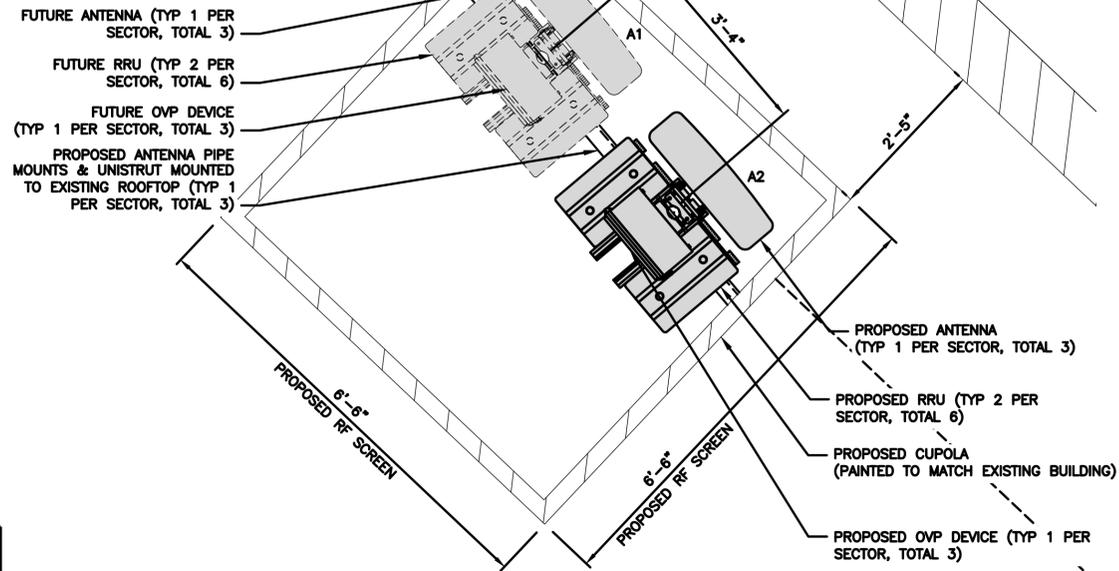

 
PROPOSED ANTENNA PLAN AND RRU PLAN – ALPHA SECTOR




1

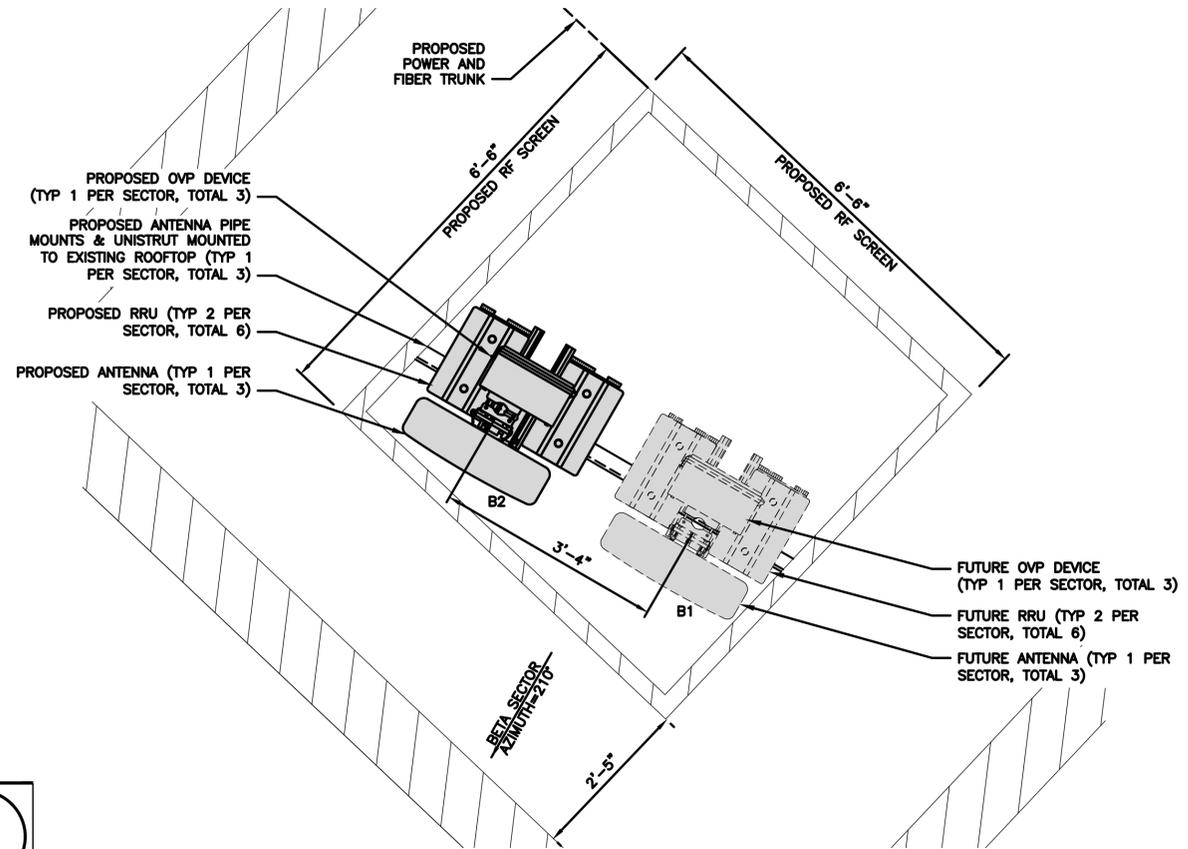

 
PROPOSED ANTENNA PLAN AND RRU PLAN – BETA SECTOR



2

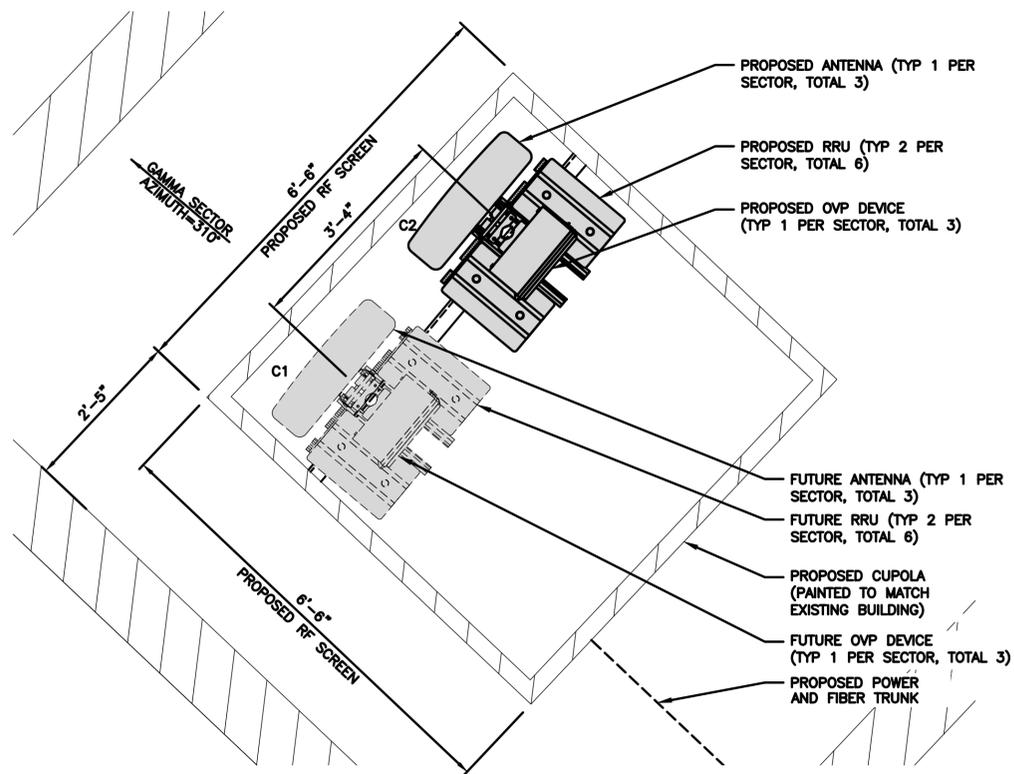

 PROPOSED ANTENNA PLAN AND RRU PLAN – GAMMA SECTOR



3

SECTOR	POSITION	ANTENNA						TRANSMISSION CABLE
		EXISTING OR PROPOSED	MANUFACTURER – MODEL NUMBER	TECHNOLOGY	SIZE (HxWxD)	AZIMUTH	RAD CENTER	
ALPHA	A1	FUTURE	ANTENNA – FUTURE/TBD	5G	72"x20"x8"	50°	42°-0"	(2) POWER AND FIBER TRUNK (100' LONG)
	A2	PROPOSED	JMA – MX08FR0665-21	5G	72"x20"x8"	50°	42°-0"	
BETA	B1	FUTURE	ANTENNA – FUTURE/TBD	5G	72"x20"x8"	210°	42°-0"	(2) POWER AND FIBER TRUNK (120' LONG)
	B2	PROPOSED	JMA – MX08FR0665-21	5G	72"x20"x8"	210°	42°-0"	
GAMMA	C1	FUTURE	ANTENNA – FUTURE/TBD	5G	72"x20"x8"	310°	42°-0"	(2) POWER AND FIBER TRUNK (130' LONG)
	C2	PROPOSED	JMA – MX08FR0665-21	5G	72"x20"x8"	310°	42°-0"	

SECTOR	POSITION	RRH			NOTES
		MANUFACTURER – MODEL NUMBER	TECHNOLOGY	SIZE (HxWxD)	
ALPHA	A1	RADIO – FUTURE/TBD	n71	16.93"x13.89"x11.1"	1. CONTRACTOR TO REFER TO FINAL CONSTRUCTION RFDS FOR ALL RF DETAILS. 2. ANTENNA AND RRH MODELS MAY CHANGE DUE TO EQUIPMENT AVAILABILITY. ALL EQUIPMENT CHANGES MUST BE APPROVED AND REMAIN IN COMPLIANCE WITH THE PROPOSED DESIGN AND STRUCTURAL ANALYSES.
	A2	RADIO – FUTURE/TBD	n70 n66	16.93"x13.89"x9.84"	
BETA	B1	MTI – G060708-50-02B	n71	16.93"x13.89"x11.1"	
	B2	MTI – G2021-49-02B	n70 n66	16.93"x13.89"x9.84"	
GAMMA	C1	RADIO – FUTURE/TBD	n71	16.93"x13.89"x11.1"	
	C2	MTI – G060708-50-02B	n70 n66	16.93"x13.89"x9.84"	

ANTENNA AND RRU SCHEDULES

NO SCALE

4



5701 SOUTH SANTA FE DRIVE
LITTLETON, CO 80120



2840 HOWE ROAD, SUITE E
MARTINEZ, CA 94553
www.TheCBRGroup.com

IT IS A VIOLATION OF LAW FOR ANY PERSON, UNLESS THEY ARE ACTING UNDER THE DIRECTION OF A LICENSED PROFESSIONAL ENGINEER, TO ALTER THIS DOCUMENT.

DRAWN BY: CHECKED BY: APPROVED BY:

MST --- ---

RFDS REV #: 2 02/09/2022

CONSTRUCTION DOCUMENTS

SUBMITTALS		
REV	DATE	DESCRIPTION
A	06/14/2022	90% CD'S ISSUED FOR REVIEW

A&E PROJECT NUMBER
SFSF00580A

DISH Wireless L.L.C.
PROJECT INFORMATION
SFSF00580A
100 FOUNTAIN GROVE PKWY
SANTA ROSA, CA 95403

SHEET TITLE
ANTENNA PLAN,
RRU PLAN AND SCHEDULES

SHEET NUMBER
A-3

NOTES

1. CONTRACTOR SHALL FIELD VERIFY ALL DIMENSIONS.
2. ANTENNA AND MW DISH SPECIFICATIONS REFER TO A ANTENNA SCHEDULE AND TO FINAL CONSTRUCTION RFDS FOR ALL RF DETAILS
3. ALL NEW EQUIPMENT TO BE PAINTED AND TEXTURED TO MATCH EXISTING BUILDING.
4. EXISTING FINISHES TO BE REPAIRED SO TEXTURE AND COLOR MATCH THE ADJACENT SURFACES.
5. ALL EXPOSED VERTICAL CABLE RUNS SHALL RECEIVE A 22 GAUGE METAL COVER PAINTED TO MATCH THE ADJACENT VERTICAL SURFACE MATERIAL.

dish
wireless.

5701 SOUTH SANTA FE DRIVE
LITTLETON, CO 80120

THE CBR GROUP

2840 HOWE ROAD, SUITE E
MARTINEZ, CA 94553
www.TheCBRGroup.com

EXISTING BUILDING ROOF
T.O. ±52'-0" AGL

EXISTING BUILDING PARAPET
T.O. ±37'-0" AGL

EXISTING BUILDING ROOFTOP
T.O. ±34'-0" AGL

EXISTING GRADE
0'-0" AGL



EXISTING SOUTHWEST ELEVATION

8' 4' 0 8' 16'
1/8"=1'-0"

1

EXISTING BUILDING ROOF
T.O. ±52'-0" AGL

PROPOSED CUPOLA
T.O. EL ±47'-6" AGL

(6) PROPOSED ANTENNA
T.O. EL ± 45'-0" AGL

(6) PROPOSED ANTENNA
RAD CENTER ± 42'-0" AGL

EXISTING BUILDING PARAPET
T.O. ±37'-0" AGL

EXISTING BUILDING ROOFTOP
T.O. ±34'-0" AGL

EXISTING GRADE
0'-0" AGL



PROPOSED SOUTHWEST ELEVATION

8' 4' 0 8' 16'
1/8"=1'-0"

2

IT IS A VIOLATION OF LAW FOR ANY PERSON, UNLESS THEY ARE ACTING UNDER THE DIRECTION OF A LICENSED PROFESSIONAL ENGINEER, TO ALTER THIS DOCUMENT.

DRAWN BY: CHECKED BY: APPROVED BY:

MST --- ---

RFDS REV #: 2 02/09/2022

CONSTRUCTION DOCUMENTS

SUBMITTALS		
REV	DATE	DESCRIPTION
A	06/14/2022	90% CD'S ISSUED FOR REVIEW

A&E PROJECT NUMBER
SFSF000580A

DISH Wireless L.L.C.
PROJECT INFORMATION
SFSF000580A
100 FOUNTAIN GROVE PKWY
SANTA ROSA, CA 95403

SHEET TITLE
EXISTING AND PROPOSED
SOUTHWEST ELEVATIONS

SHEET NUMBER
A-4

NOTES

1. CONTRACTOR SHALL FIELD VERIFY ALL DIMENSIONS.
2. ANTENNA AND MW DISH SPECIFICATIONS REFER TO A ANTENNA SCHEDULE AND TO FINAL CONSTRUCTION RFDS FOR ALL RF DETAILS
3. ALL NEW EQUIPMENT TO BE PAINTED AND TEXTURED TO MATCH EXISTING BUILDING.
4. EXISTING FINISHES TO BE REPAIRED SO TEXTURE AND COLOR MATCH THE ADJACENT SURFACES.
5. ALL EXPOSED VERTICAL CABLE RUNS SHALL RECEIVE A 22 GAUGE METAL COVER PAINTED TO MATCH THE ADJACENT VERTICAL SURFACE MATERIAL.



5701 SOUTH SANTA FE DRIVE
LITTLETON, CO 80120




2840 HOWE ROAD, SUITE E
MARTINEZ, CA 94553
www.TheCBRGroup.com

EXISTING BUILDING ROOF
T.O. 52'-0" AGL

EXISTING BUILDING PARAPET
T.O. ±37'-0" AGL

EXISTING BUILDING ROOFTOP
T.O. ±34'-0" AGL

EXISTING GRADE
0'-0" AGL

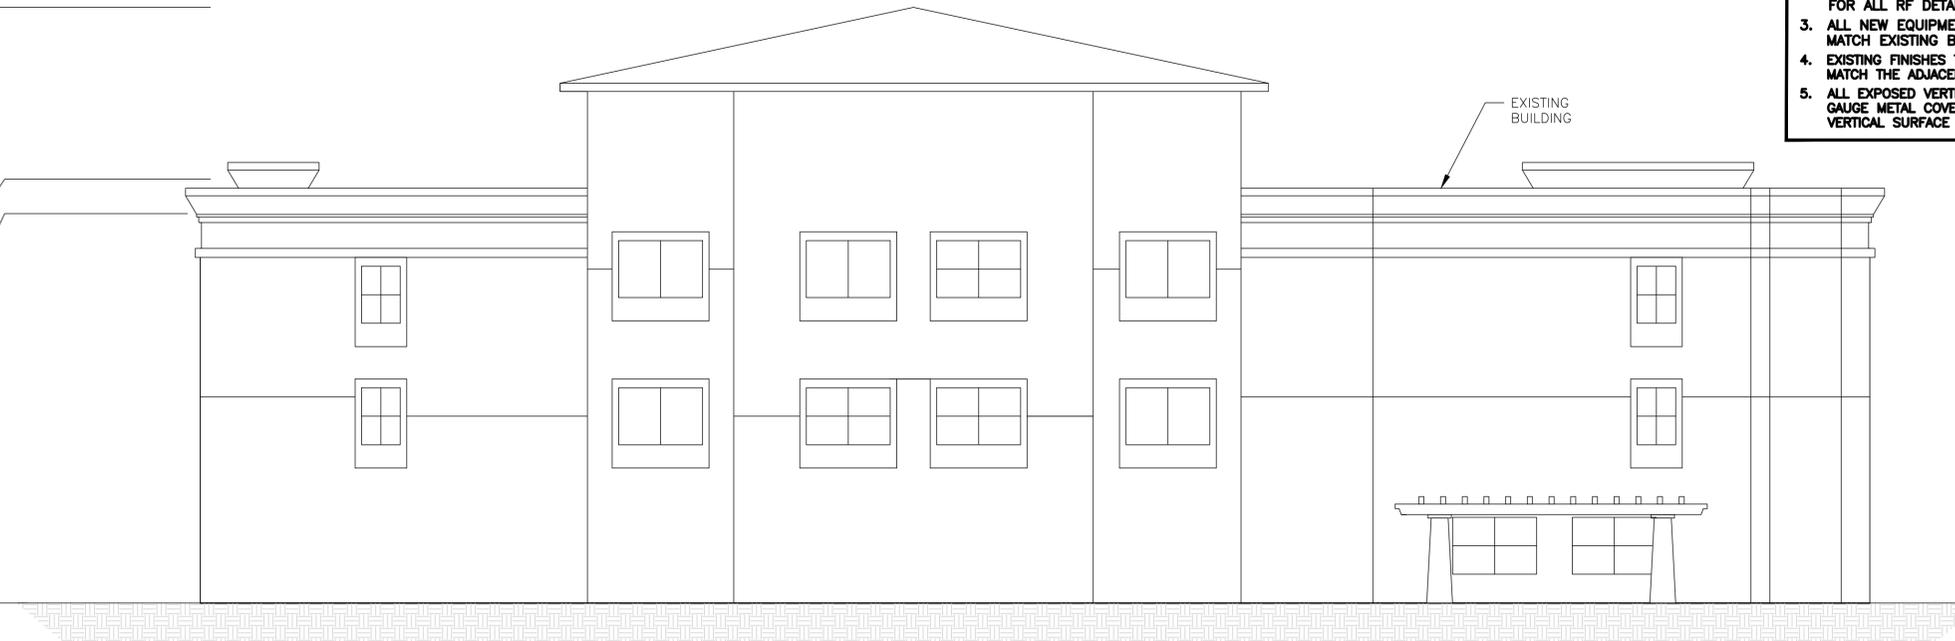

EXISTING NORTHWEST ELEVATION

8' 4' 0 8' 16'
1/8"=1'-0"

1

EXISTING BUILDING ROOF
T.O. 52'-0" AGL

PROPOSED CUPOLA
T.O. EL 47'-6" AGL

(6) PROPOSED ANTENNA
T.O. EL ± 45'-0" AGL


(6) PROPOSED ANTENNA
RAD CENTER ± 42'-0" AGL

EXISTING BUILDING PARAPET
T.O. ±37'-0" AGL

EXISTING BUILDING ROOFTOP
T.O. ±34'-0" AGL

EXISTING GRADE
0'-0" AGL

- PROPOSED CUPOLA (PAINTED TO MATCH EXISTING BUILDING)
- PROPOSED ANTENNA (TYP 2 PER SECTOR, TOTAL 6)
- PROPOSED OVP DEVICE (TYP 2 PER SECTOR, TOTAL 6)
- PROPOSED RRU (TYP 4 PER SECTOR, TOTAL 12)
- PROPOSED ENLARGED EQUIPMENT AREA AT GROUND LEVEL INSIDE CHAIN-LINK FENCE WITH LOCK (BEHIND BUILDING)

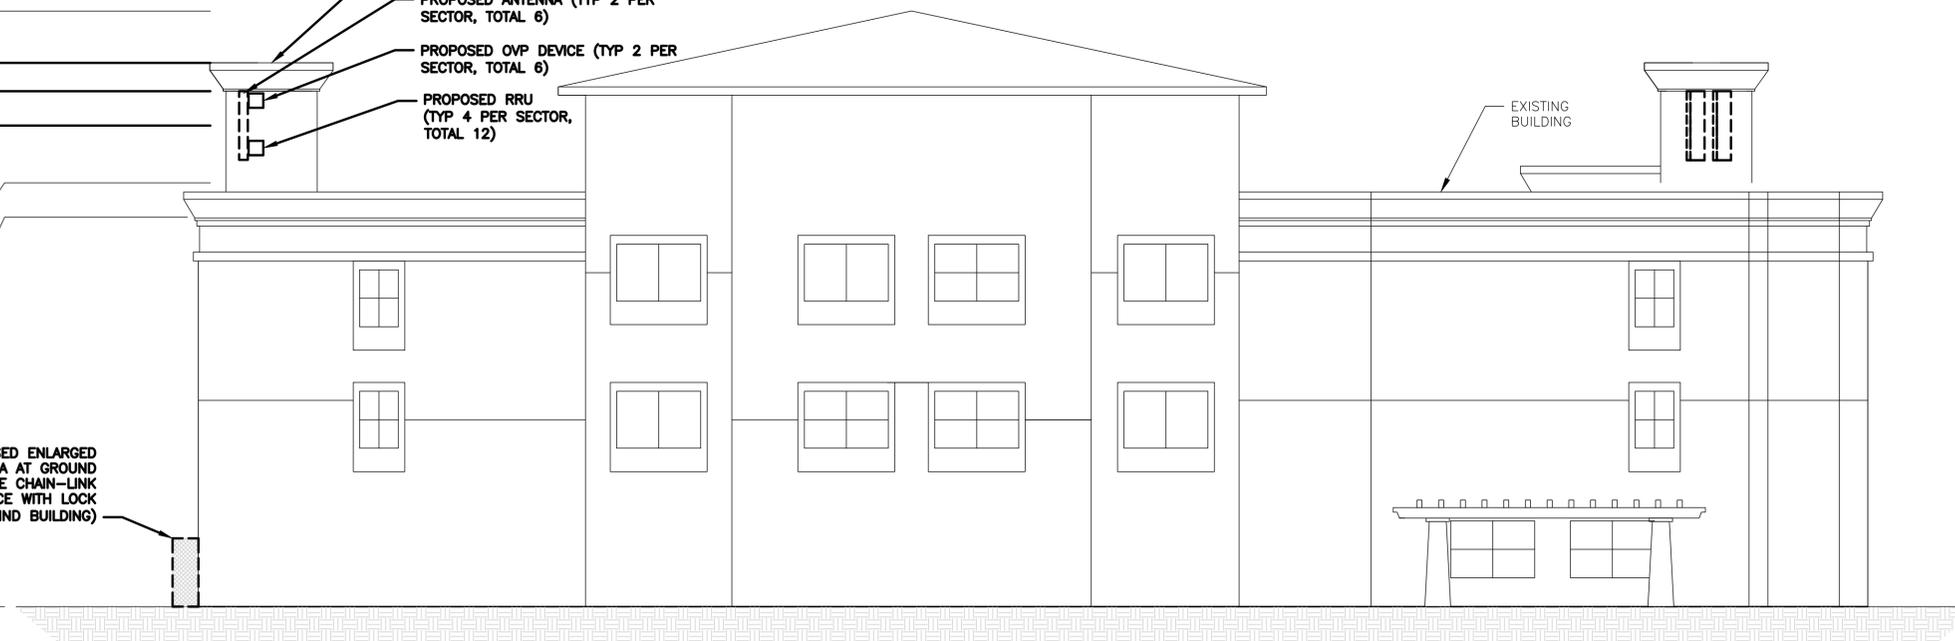

PROPOSED NORTHWEST ELEVATION

8' 4' 0 8' 16'
1/8"=1'-0"

2

IT IS A VIOLATION OF LAW FOR ANY PERSON, UNLESS THEY ARE ACTING UNDER THE DIRECTION OF A LICENSED PROFESSIONAL ENGINEER, TO ALTER THIS DOCUMENT.

DRAWN BY: CHECKED BY: APPROVED BY:

MST --- ---

RFDS REV #: 2 02/09/2022

CONSTRUCTION DOCUMENTS


SUBMITTALS		
REV	DATE	DESCRIPTION
A	06/14/2022	90% CD'S ISSUED FOR REVIEW

A&E PROJECT NUMBER
SFSF000580A



DISH Wireless L.L.C.
PROJECT INFORMATION
SFSF000580A
100 FOUNTAIN GROVE PKWY
SANTA ROSA, CA 95403

SHEET TITLE
EXISTING AND PROPOSED
NORTHWEST ELEVATIONS


SHEET NUMBER
A-5

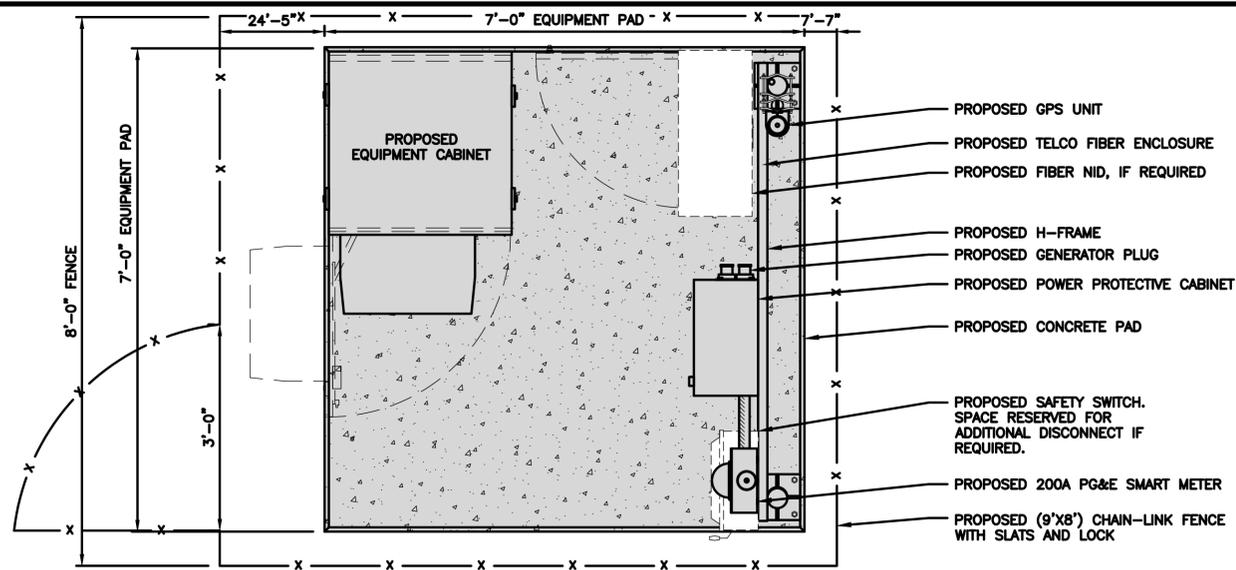


PLATFORM EQUIPMENT PLAN

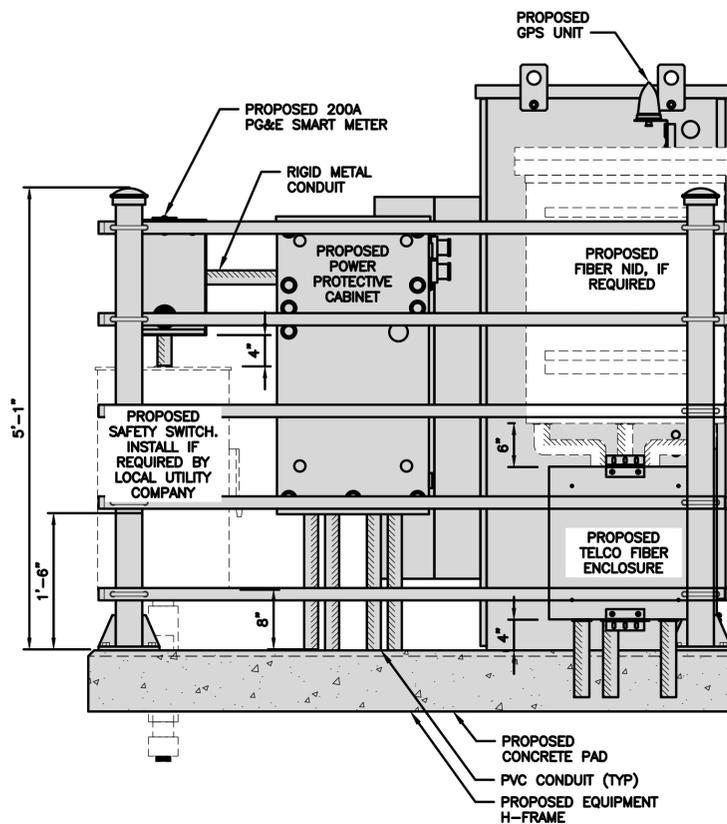 

FRONT ELEVATION

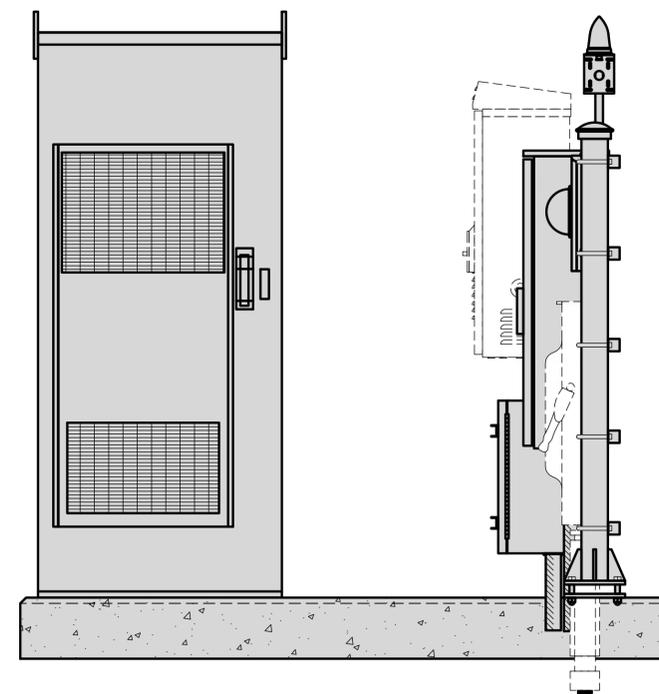

SIDE ELEVATION

 


H-FRAME EQUIPMENT ELEVATION


NO SCALE 2

COMMSCOPE MTC4045HFLD H-FRAME	
UNISTRUT/SUPPORT RAILS QTY	5
WEIGHT	59.74 lbs

NOTE:
OR DISH Wireless L.L.C.
APPROVED EQUIVALENT

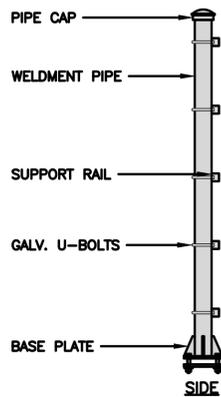


H-FRAME DETAIL

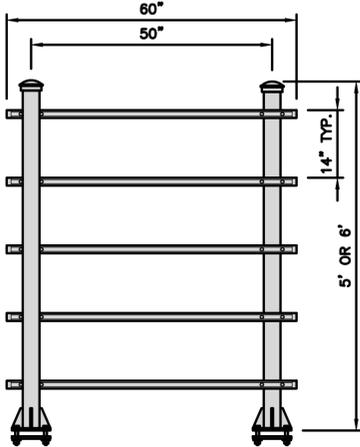

FRONT

NO SCALE 4

NO SCALE 3

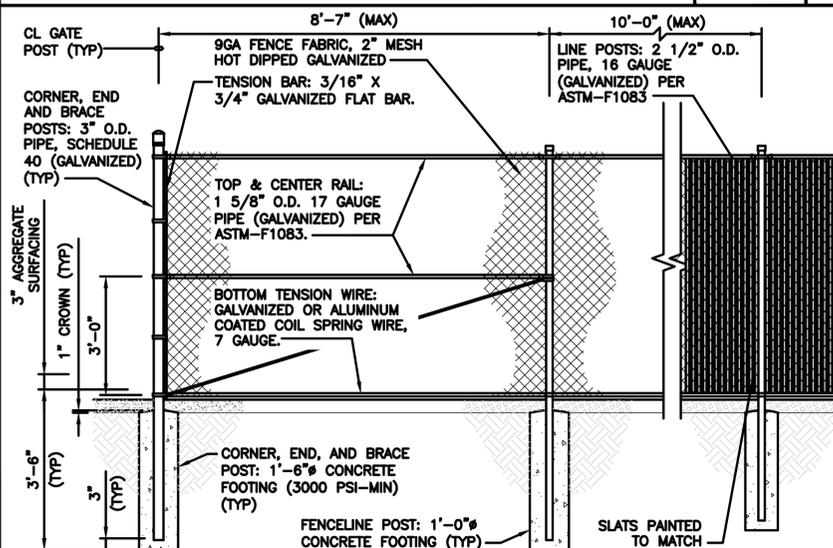

TYPICAL FENCE DETAIL

NO SCALE 5

dish
wireless.

5701 SOUTH SANTA FE DRIVE
LITTLETON, CO 80120

THE CBR GROUP

2840 HOWE ROAD, SUITE E
MARTINEZ, CA 94553
www.TheCBRGroup.com

IT IS A VIOLATION OF LAW FOR ANY PERSON, UNLESS THEY ARE ACTING UNDER THE DIRECTION OF A LICENSED PROFESSIONAL ENGINEER, TO ALTER THIS DOCUMENT.

DRAWN BY: CHECKED BY: APPROVED BY:

MST --- ---

RFDS REV #: 2 02/09/2022

CONSTRUCTION DOCUMENTS

SUBMITTALS		
REV	DATE	DESCRIPTION
A	06/14/2022	90% CD'S ISSUED FOR REVIEW

A&E PROJECT NUMBER

SFSF000580A

DISH Wireless L.L.C.
PROJECT INFORMATION



SFSF000580A
100 FOUNTAIN GROVE PKWY
SANTA ROSA, CA 95403

SHEET TITLE
EQUIPMENT PLATFORM AND
H-FRAME DETAILS

SHEET NUMBER

A-6



CHARLES INDUSTRY HEX CUBE-PM639155N4	
DIMENSIONS (HxWxD)	74"x32"x32"
POWER PLANT	-48VDC ABB/600W
TOTAL WEIGHT (EMPTY)	408 lbs

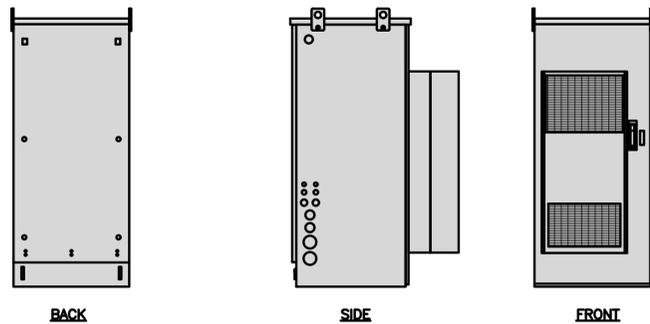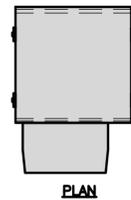

CABINET DETAIL

NO SCALE 1



RAYCAP PPC RDIAC-2465-P-240-MTS	
ENCLOSURE DIMENSIONS (HxWxD):	39"x22.855"x12.593
WEIGHT:	80 lbs
OPERATING AC VOLTAGE	240/120 1 PHASE 3W+G

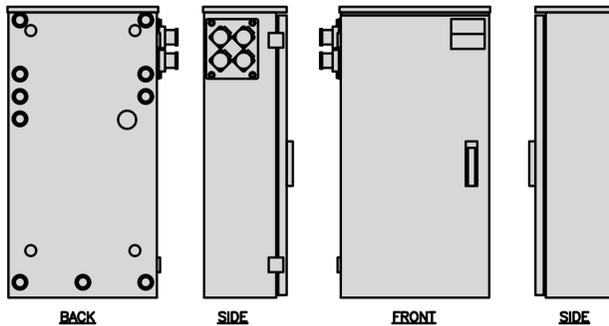 

CABINET DETAIL

NO SCALE 2



SQUARE D SAFETY SWITCHES D224NRB	
ENCLOSURE DIM (HxWxD)	29.25"x19.00"x8.50"
ENCLOSURE TYPE	NEMA 3R RAINPROOF
UL LISTED	FILE E-2875

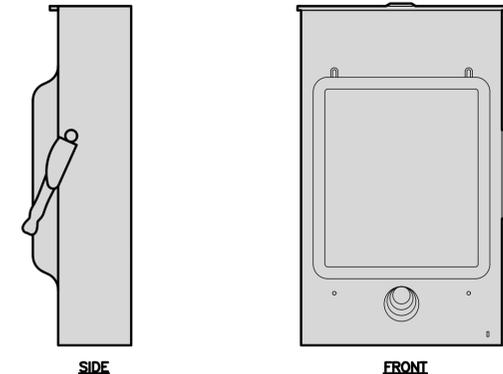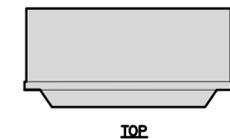

SAFETY SWITCH DETAIL

NO SCALE 3



LEVITON 1N240-2D SUBMETER	
WIRE	3
AMPS	200
VOLTS AC	120, 208, 240
PHASE	1

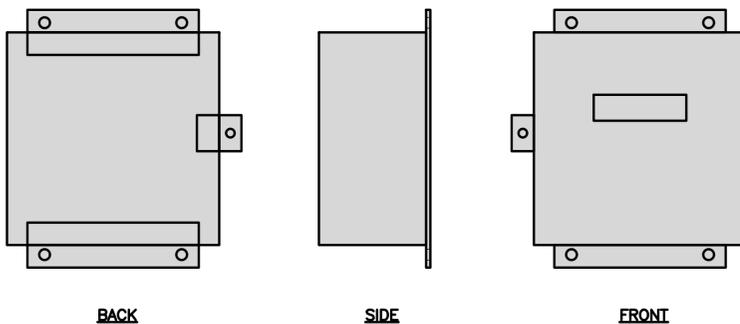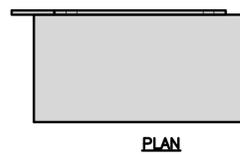

SUBMETER DETAIL

NO SCALE 4


ZAYO 5RU (LEFT SWING DOOR) FIBER NID ENCLOSURE	
DIMENSIONS (HxWxD)	36.1"x29"x12.9"
WEIGHT	85 lbs

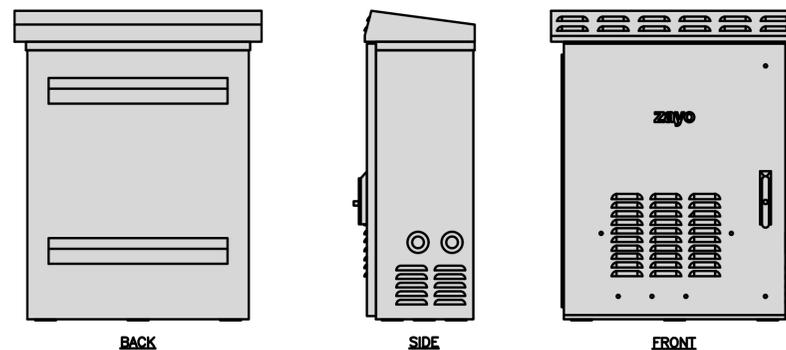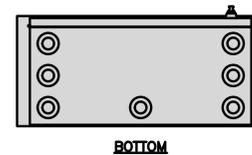

FIBER NID ENCLOSURE DETAIL

NO SCALE 5



CHARLES CFIT-PF2020DSH1 FIBER TELCO ENCLOSURE	
ENCLOSURE DIMS (HxWxD)	20"x20"x9"
ENCLOSURE WEIGHT	20 lbs
MOUNTING	WALL
COMPLIANCE	TYPE 4

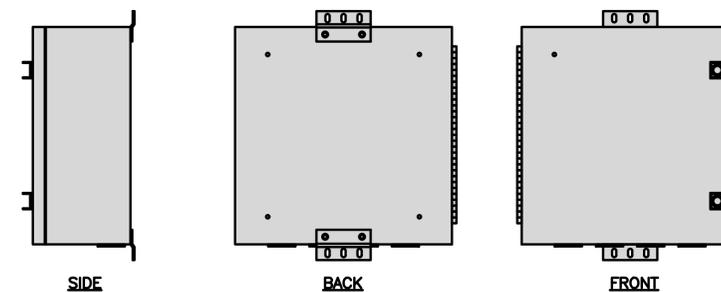

FIBER TELCO ENCLOSURE DETAIL


NO SCALE 6

PCTEL GPSGL-TMG-SPI-40NCB	
DIMENSIONS (DIAxH) MM/INCH	81x184mm 3.2"x7.25"
WEIGHT W/ACCESSORIES	075 lbs
CONNECTOR	N-FEMALE
FREQUENCY RANGE	1590 ± 30MHz

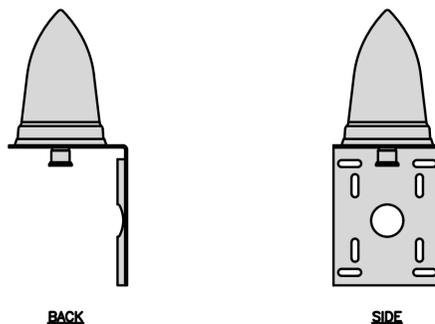 


GPS DETAIL

NO SCALE 7

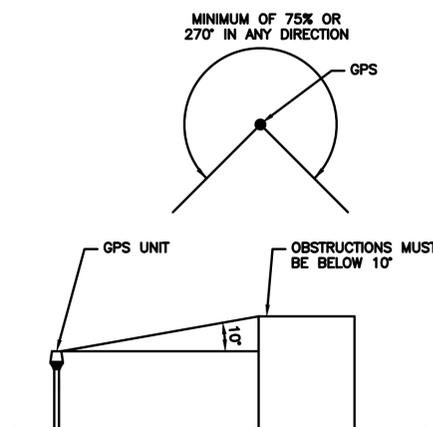

GPS MINIMUM SKY VIEW REQUIREMENTS

NO SCALE 8

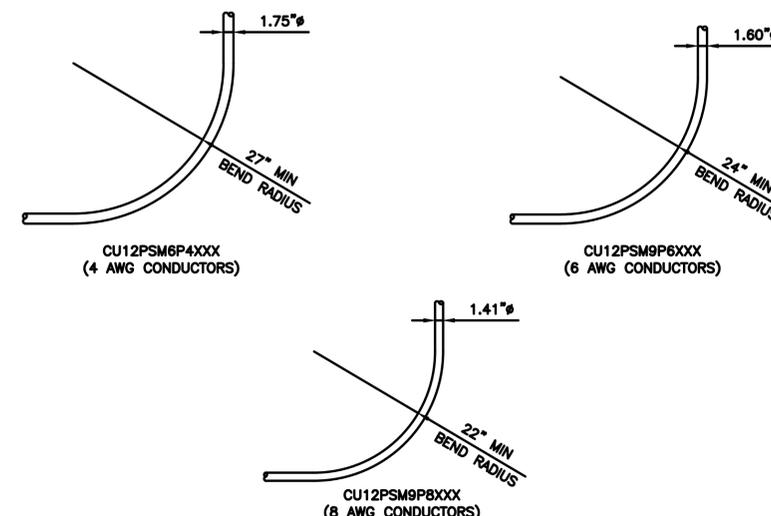

CABLES UNLIMITED HYBRID CABLE MINIMUM BEND RADIUSES

NO SCALE 9



5701 SOUTH SANTA FE DRIVE
LITTLETON, CO 80120



2840 HOWE ROAD, SUITE E
MARTINEZ, CA 94553
www.TheCBRGroup.com

IT IS A VIOLATION OF LAW FOR ANY PERSON, UNLESS THEY ARE ACTING UNDER THE DIRECTION OF A LICENSED PROFESSIONAL ENGINEER, TO ALTER THIS DOCUMENT.

DRAWN BY: CHECKED BY: APPROVED BY:
MST --- ---

RFDS REV #: 2 02/09/2022

CONSTRUCTION DOCUMENTS

SUBMITTALS		
REV	DATE	DESCRIPTION
A	06/14/2022	90% CD'S ISSUED FOR REVIEW


A&E PROJECT NUMBER
SFSF000580A

DISH Wireless L.L.C.
PROJECT INFORMATION
SFSF000580A
100 FOUNTAIN GROVE PKWY
SANTA ROSA, CA 95403


SHEET TITLE
EQUIPMENT DETAILS

SHEET NUMBER
A-7


MTI TB GEN-1.5 G060708-50-02B	
DIMENSIONS (HxWxD)	13.9"x16.9"x11"
WEIGHT	97 lbs
DC POWER IN	-40.5V to -57V
POWER SUPPLY VOLTAGE	-48Vdc (NOMINAL)

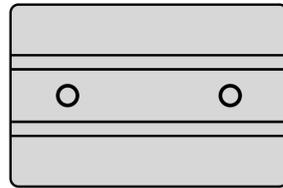

PLAN

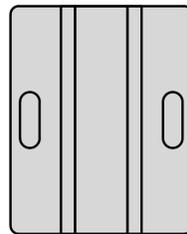

SIDE

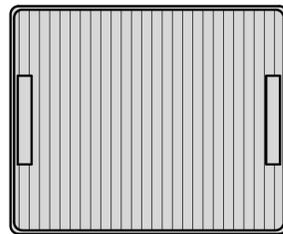


FRONT

RRH DETAIL


NO SCALE

1


MTI DB GEN-1.5 G2021-49-02B	
DIMENSIONS (HxWxD)	13.9"x16.9"x9.8"
WEIGHT	86 lbs
DC POWER IN	-40.5V to -57V
POWER SUPPLY VOLTAGE	-48Vdc (NOMINAL)

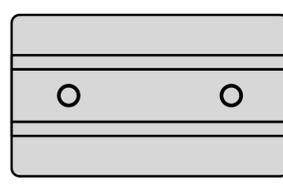

PLAN

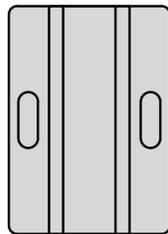

SIDE

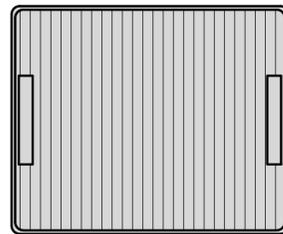

FRONT



RRH DETAIL

NO SCALE

2

SABRE DOUBLE Z-BRACKET C10123155	
DIMENSIONS (HxWxD) (1 BRACKET)	5"x20"x1-13/16"
WEIGHT (FULL ASSEMBLY)	35.79 lbs
PACKAGE QUANTITY	4

#	DESCRIPTION
1	PLATE, CHANNEL BRACKET
2	RRH Z BRACKET, 3/16"
3	THREADED ROD ASSEMBLY 1/2"x12"

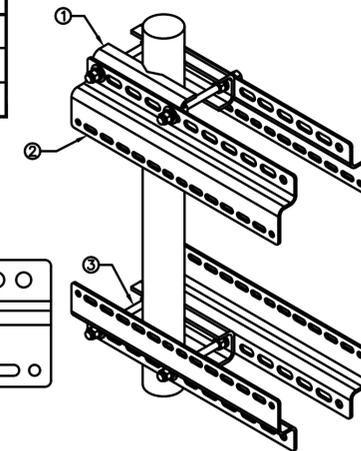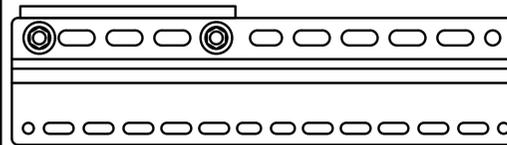


NOTE:
OR DISH Wireless L.L.C.
APPROVED EQUIVALENT

RRH MOUNT DETAIL


NO SCALE

3


JMA MX08FRO665-21	
DIMENSIONS (HxWxD)	72"x20.0"x8.0"
RF PORTS, CONNECTOR TYPE	8 x 4.3-10 FEMALE
WEIGHT	64.5 lbs
WEIGHT WITH BRACKETS	82.5 lbs

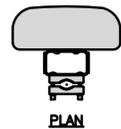

PLAN

 

SIDE

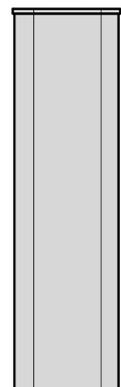

FRONT

ANTENNA DETAIL


NO SCALE

4


RAYCAP RDIDC-3045-PF-48 SURGE PROTECTION DEVICE (OVP)	
DIMENSIONS (HxWxD)	19"x16.21"x9.64"
WEIGHT	21 lbs




PLAN

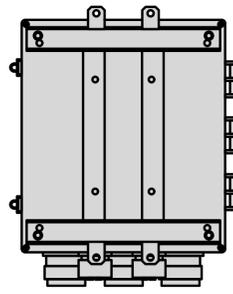

BACK

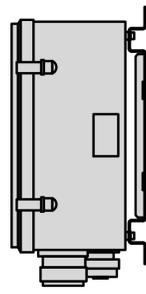

SIDE

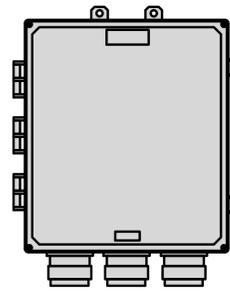

FRONT


SURGE PROTECTION DEVICE (OVP) DETAIL

NO SCALE

5

JMA ANTENNA MOUNT BRACKET #91900318	
TOTAL WEIGHT (WITH BRACKETS)	18 lbs (8.18 Kg)
POLE DIAMETER RANGE	2.5" TO 4.5"

NOTE:
KIT #91900318: TOP AND BOTTOM BRACKETS
FOR 4-, 6-, AND 8-FOOT ANTENNAS
ANTENNA BRACKET NOT PART OF KIT

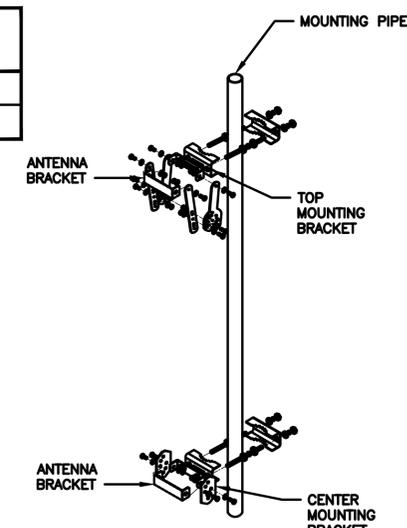

NOTE:
OR DISH Wireless L.L.C.
APPROVED EQUIVALENT

ANTENNA BRACKET DETAIL

NO SCALE

6

NO SCALE

7

NO SCALE

8

NO SCALE

9



5701 SOUTH SANTA FE DRIVE
LITTLETON, CO 80120



2840 HOWE ROAD, SUITE E
MARTINEZ, CA 94553
www.TheCBRGroup.com

IT IS A VIOLATION OF LAW FOR ANY PERSON,
UNLESS THEY ARE ACTING UNDER THE DIRECTION
OF A LICENSED PROFESSIONAL ENGINEER,
TO ALTER THIS DOCUMENT.

DRAWN BY: CHECKED BY: APPROVED BY:

MST --- ---

RFDS REV #: 2 02/09/2022

CONSTRUCTION DOCUMENTS


SUBMITTALS		
REV	DATE	DESCRIPTION
A	06/14/2022	90% CD'S ISSUED FOR REVIEW

A&E PROJECT NUMBER
SFSF000580A

DISH Wireless L.L.C.
PROJECT INFORMATION
SFSF000580A
100 FOUNTAIN GROVE PKWY
SANTA ROSA, CA 95403

SHEET TITLE
EQUIPMENT DETAILS

SHEET NUMBER
A-8

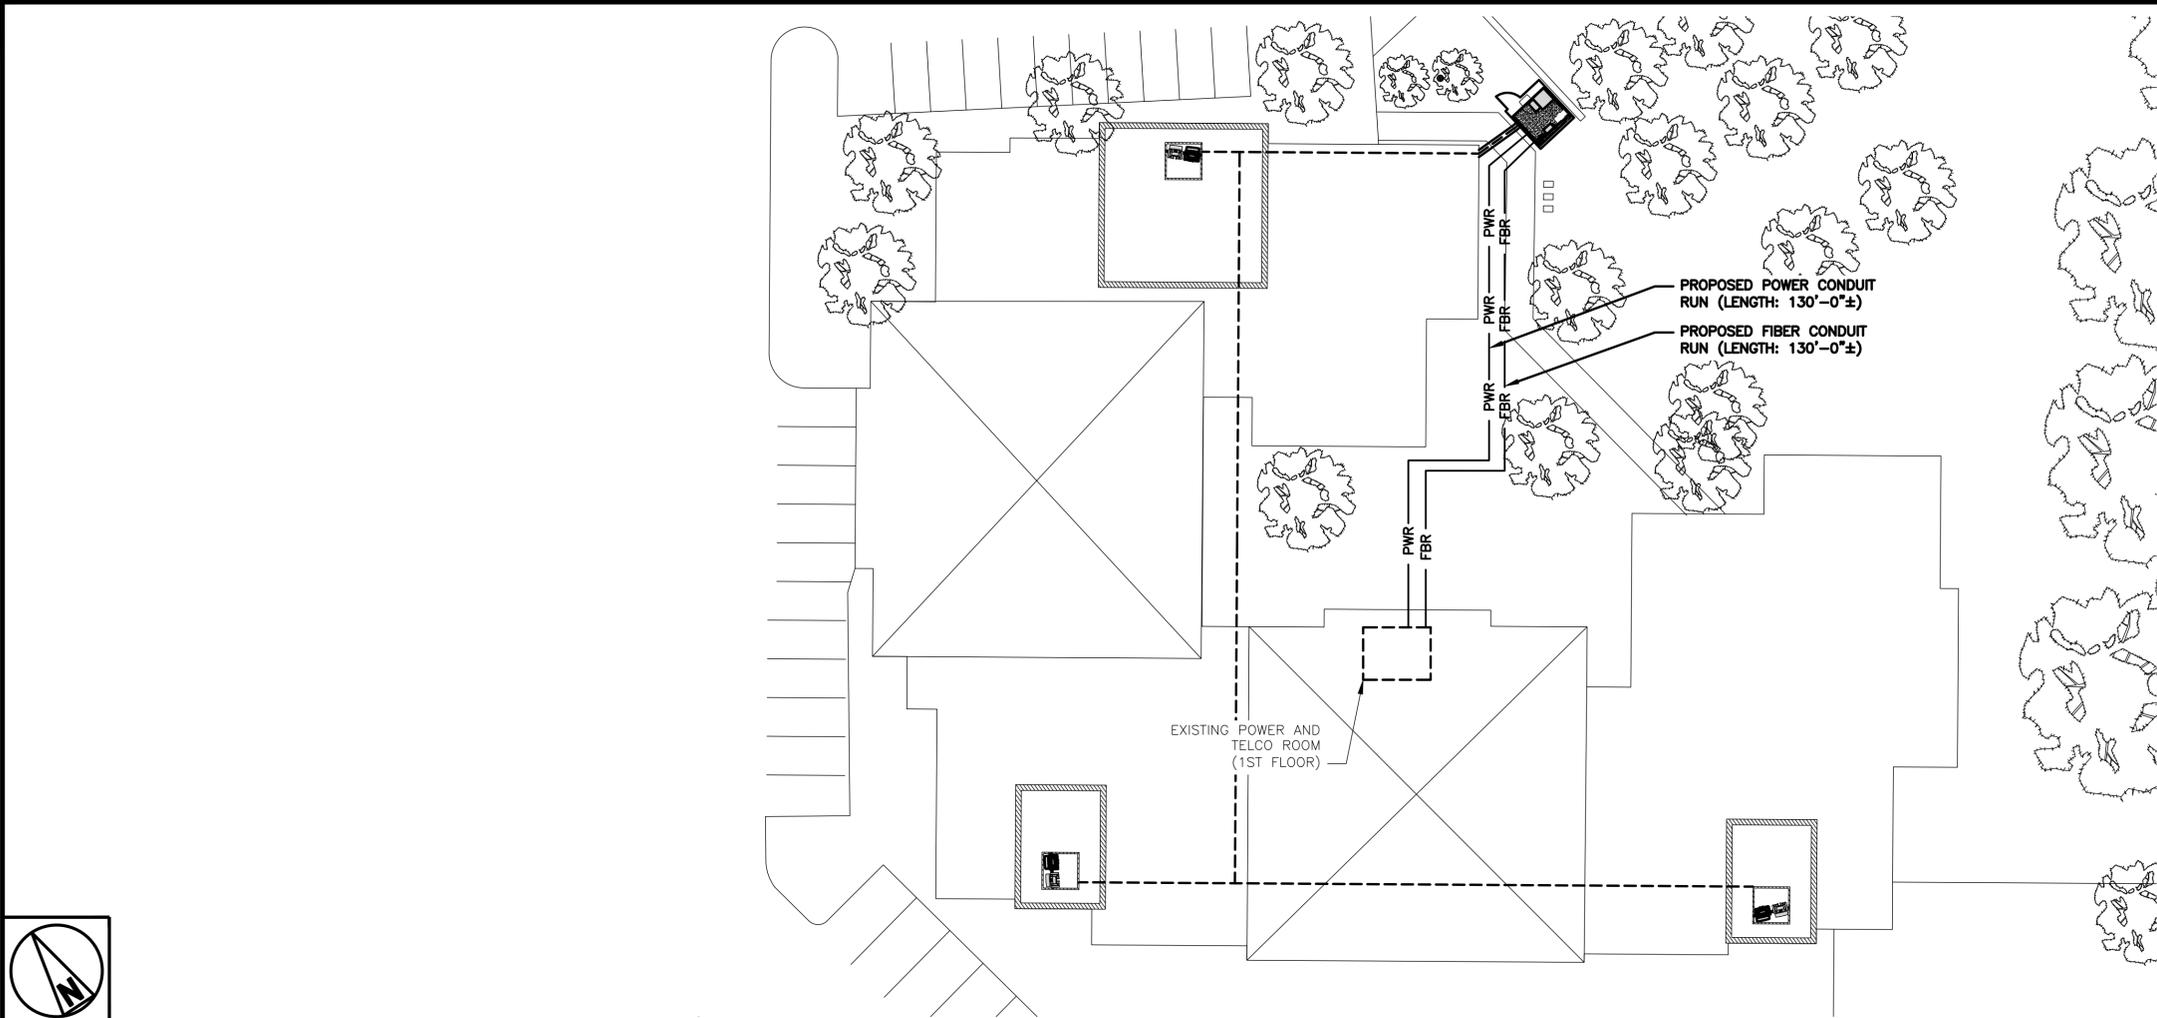

NOTE
CONTRACTOR SHALL FIELD VERIFY ALL DIMENSIONS.



 
5701 SOUTH SANTA FE DRIVE
LITTLETON, CO 80120



2840 HOWE ROAD, SUITE E
MARTINEZ, CA 94553
www.TheCBRGroup.com

IT IS A VIOLATION OF LAW FOR ANY PERSON, UNLESS THEY ARE ACTING UNDER THE DIRECTION OF A LICENSED PROFESSIONAL ENGINEER, TO ALTER THIS DOCUMENT.

UTILITY ROUTE PLAN



1

DRAWN BY: CHECKED BY: APPROVED BY:
MST --- ---
RFDS REV #: 2 02/09/2022

CONSTRUCTION DOCUMENTS


SUBMITTALS		
REV	DATE	DESCRIPTION
A	06/14/2022	90% CD'S ISSUED FOR REVIEW

A&E PROJECT NUMBER
SFSF000580A


DISH Wireless L.L.C.
PROJECT INFORMATION
SFSF000580A
100 FOUNTAIN GROVE PKWY
SANTA ROSA, CA 95403

SHEET TITLE
ELECTRICAL/FIBER ROUTE
PLAN AND NOTES

SHEET NUMBER
E-1

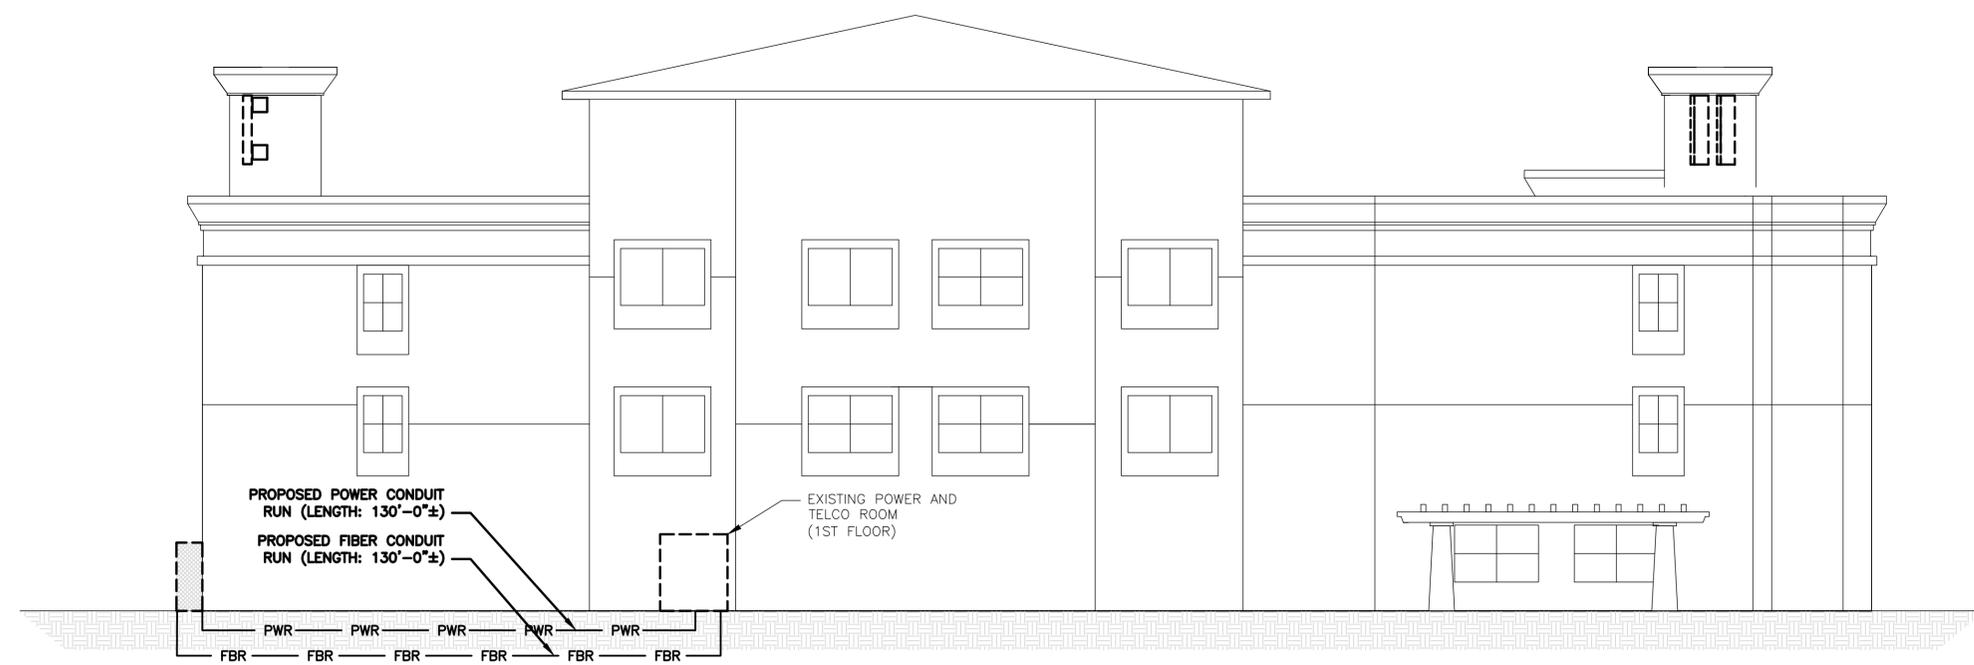


UTILITY ROUTE ELEVATION

 

2

DC POWER WIRING SHALL BE COLOR CODED AT EACH END FOR IDENTIFYING +24V AND -48V CONDUCTORS. RED MARKINGS SHALL IDENTIFY +24V AND BLUE MARKINGS SHALL IDENTIFY -48V.

- CONTRACTOR SHALL INSPECT THE EXISTING CONDITIONS PRIOR TO SUBMITTING A BID. ANY QUESTIONS ARISING DURING THE BID PERIOD IN REGARDS TO THE CONTRACTOR'S FUNCTIONS, THE SCOPE OF WORK, OR ANY OTHER ISSUE RELATED TO THIS PROJECT SHALL BE BROUGHT UP DURING THE BID PERIOD WITH THE PROJECT MANAGER FOR CLARIFICATION, NOT AFTER THE CONTRACT HAS BEEN AWARDED.
- ALL ELECTRICAL WORK SHALL BE DONE IN ACCORDANCE WITH CURRENT NATIONAL ELECTRICAL CODES AND ALL STATE AND LOCAL CODES, LAWS, AND ORDINANCES. PROVIDE ALL COMPONENTS AND WIRING SIZES AS REQUIRED TO MEET NEC STANDARDS.
- LOCATION OF EQUIPMENT, CONDUIT AND DEVICES SHOWN ON THE DRAWINGS ARE APPROXIMATE AND SHALL BE COORDINATED WITH FIELD CONDITIONS PRIOR TO CONSTRUCTION.
- CONDUIT ROUGH-IN SHALL BE COORDINATED WITH THE MECHANICAL EQUIPMENT TO AVOID LOCATION CONFLICTS. VERIFY WITH THE MECHANICAL EQUIPMENT CONTRACTOR AND COMPLY AS REQUIRED.
- CONTRACTOR SHALL PROVIDE ALL BREAKERS, CONDUITS AND CIRCUITS AS REQUIRED FOR A COMPLETE SYSTEM.
- CONTRACTOR SHALL PROVIDE PULL BOXES AND JUNCTION BOXES AS REQUIRED BY THE NEC ARTICLE 314.
- CONTRACTOR SHALL PROVIDE ALL STRAIN RELIEF AND CABLE SUPPORTS FOR ALL CABLE ASSEMBLIES. INSTALLATION SHALL BE IN ACCORDANCE WITH MANUFACTURER'S SPECIFICATIONS AND RECOMMENDATIONS.
- ALL DISCONNECTS AND CONTROLLING DEVICES SHALL BE PROVIDED WITH ENGRAVED PHENOLIC NAMEPLATES INDICATING EQUIPMENT CONTROLLED, BRANCH CIRCUITS INSTALLED ON, AND PANEL FIELD LOCATIONS FED FROM.
- INSTALL AN EQUIPMENT GROUNDING CONDUCTOR IN ALL CONDUITS PER THE SPECIFICATIONS AND NEC 250. THE EQUIPMENT GROUNDING CONDUCTORS SHALL BE BONDED AT ALL JUNCTION BOXES, PULL BOXES, AND ALL DISCONNECT SWITCHES, AND EQUIPMENT CABINETS.
- ALL NEW MATERIAL SHALL HAVE A U.L. LABEL.
- PANEL SCHEDULE LOADING AND CIRCUIT ARRANGEMENTS REFLECT POST-CONSTRUCTION EQUIPMENT.
- CONTRACTOR SHALL BE RESPONSIBLE FOR AS-BUILT PANEL SCHEDULE AND SITE DRAWINGS.

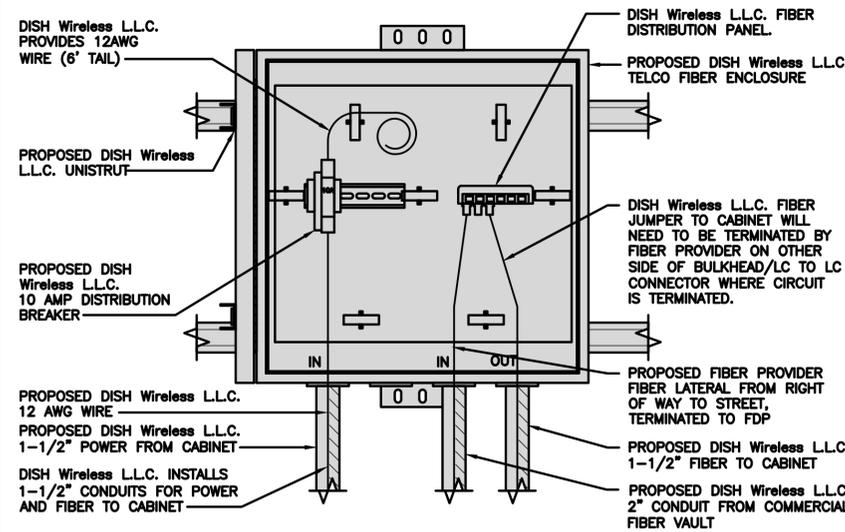

DARK TELCO BOX – INTERIOR WIRING LAYOUT

NO SCALE 2


INTERSECT CAM-LOCK GENERATOR CONNECTOR ICGC-1P	
ENCLOSURE DIMENSIONS (HxWxD):	23"x10"x9.5"
WEIGHT:	14 lbs
OPERATING AC VOLTAGE	400A, 208/120V



TOP




SIDE

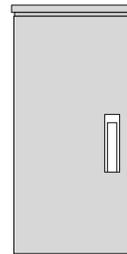

FRONT

GEN PLUG DETAIL

NO SCALE 4

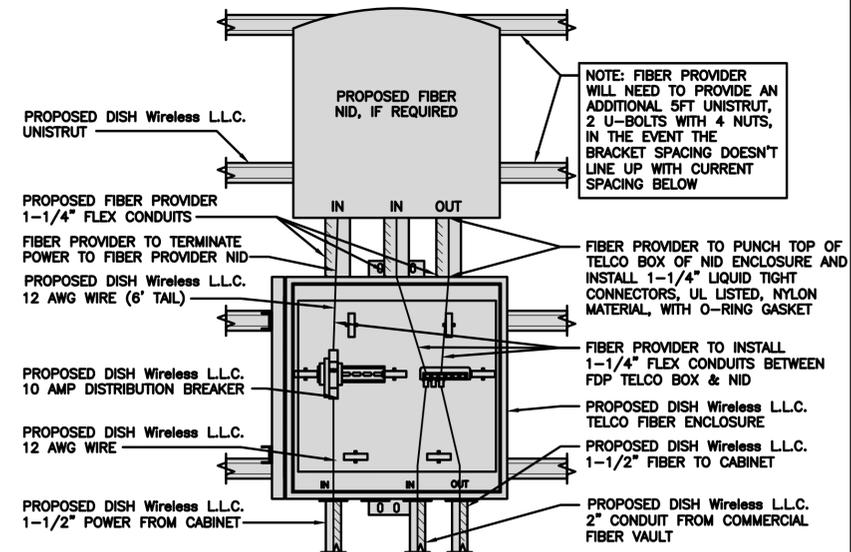

LIT TELCO BOX – INTERIOR WIRING LAYOUT (OPTIONAL)

NO SCALE 3

ELECTRICAL NOTES

NO SCALE 1

NOT USED

NO SCALE 5

NOT USED

NO SCALE 6

NOT USED

NO SCALE 7

NOT USED

NO SCALE 8



5701 SOUTH SANTA FE DRIVE
LITTLETON, CO 80120



2840 HOWE ROAD, SUITE E
MARTINEZ, CA 94553
www.TheCBRGroup.com

IT IS A VIOLATION OF LAW FOR ANY PERSON, UNLESS THEY ARE ACTING UNDER THE DIRECTION OF A LICENSED PROFESSIONAL ENGINEER, TO ALTER THIS DOCUMENT.

DRAWN BY: CHECKED BY: APPROVED BY:

MST --- ---

RFDS REV #: 2 02/09/2022

CONSTRUCTION DOCUMENTS

SUBMITTALS		
REV	DATE	DESCRIPTION
A	06/14/2022	90% CD'S ISSUED FOR REVIEW

A&E PROJECT NUMBER
SFSF000580A

DISH Wireless L.L.C.
PROJECT INFORMATION
SFSF000580A
100 FOUNTAIN GROVE PKWY
SANTA ROSA, CA 95403



SHEET TITLE
ELECTRICAL
DETAILS

SHEET NUMBER

E-2

CONSTRUCTION NOTE

- CONTRACTOR TO TAP AT THE (E) 2000A SWITCHGEAR IN THE ELECTRICAL ROOM AND INSTALL (N) SUBMETER AT AN APPROPRIATE PLACE.
- CONTRACTOR TO FIND APPROPRIATE AND ACCESSIBLE PLACE TO INSTALL CAMLOCK GENERATOR CONNECTOR INTERSECT ICL AND RUN (N) 3" CONDUIT FROM CAMLOCK TO THE PPC CABINET

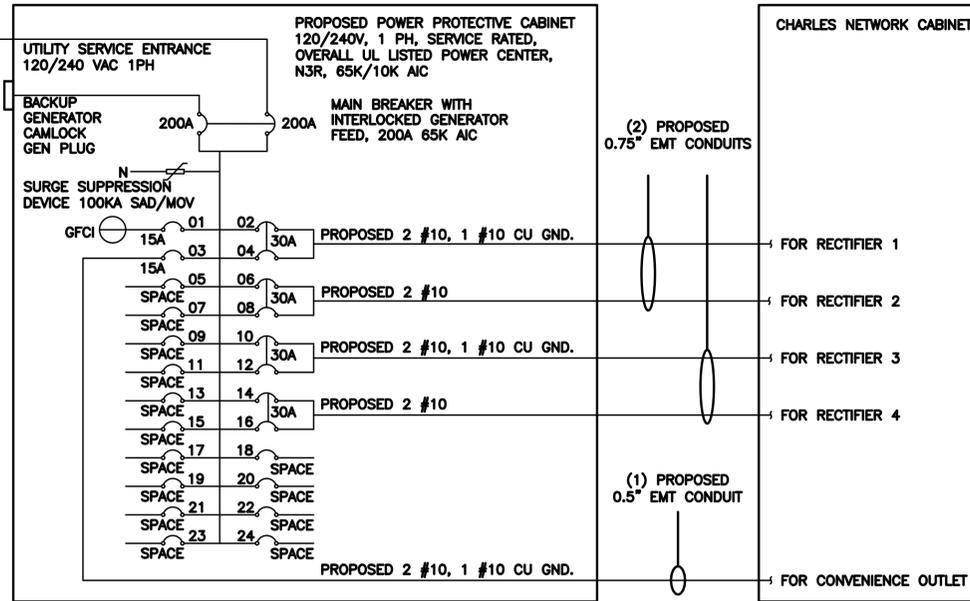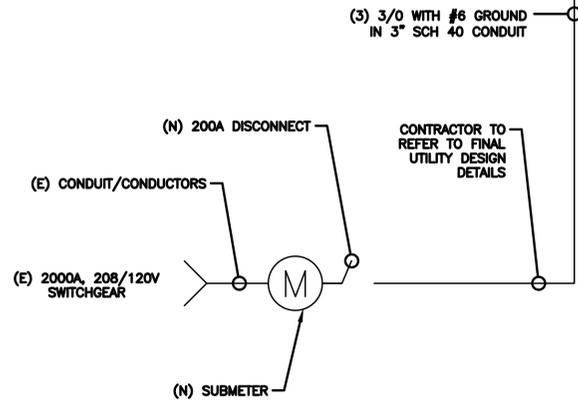

NOTE:
BRANCH CIRCUIT WIRING SUPPLYING RECTIFIERS ARE TO BE RATED UL1015, 105°C, 600V, AND PVC INSULATED, IN THE SIZES SHOWN IN THE ONE-LINE DIAGRAM. CONTRACTOR MAY SUBSTITUTE UL1015 WIRE FOR THWN-2 FOR CONVENIENCE OUTLET BRANCH CIRCUIT.

BREAKERS REQUIRED:
(4) 30A, 2P BREAKER - SQUARE D P/N:Q0230
(1) 15A, 1P BREAKER - SQUARE D P/N:Q0115

NOTES

THE ENGINEER OF RECORD HAS PERFORMED ALL REQUIRED SHORT CIRCUIT CALCULATIONS AND THE AIC RATINGS FOR EACH DEVICE IS ADEQUATE TO PROTECT THE EQUIPMENT AND THE ELECTRICAL SYSTEM.

THE ENGINEER OF RECORD HAS PERFORMED ALL REQUIRED VOLTAGE DROP CALCULATIONS AND ALL BRANCH CIRCUIT AND FEEDERS COMPLY WITH THE NEC (LISTED ON T-1) ARTICLE 210.19(A)(1) FPN NO. 4.

CONDUIT SIZING: AT 40% FILL PER NEC CHAPTER 9, TABLE 4, ARTICLE 358.
 0.5" CONDUIT - 0.122 SQ. IN AREA
 0.75" CONDUIT - 0.213 SQ. IN AREA
 2.0" CONDUIT - 1.316 SQ. IN AREA
 3.0" CONDUIT - 2.907 SQ. IN AREA

CABINET CONVENIENCE OUTLET CONDUCTORS (1 CONDUIT): USING THWN-2, CU.
 #10 - 0.0211 SQ. IN X 2 = 0.0422 SQ. IN
 #10 - 0.0211 SQ. IN X 1 = 0.0211 SQ. IN <GROUND
TOTAL = 0.0633 SQ. IN

0.5" EMT CONDUIT IS ADEQUATE TO HANDLE THE TOTAL OF (3) WIRES, INCLUDING GROUND WIRE, AS INDICATED ABOVE.

RECTIFIER CONDUCTORS (3 CONDUITS): USING UL1015, CU.
 #8 - 0.0552 SQ. IN X 2 = 0.1103 SQ. IN
 #8 - 0.0131 SQ. IN X 1 = 0.0131 SQ. IN <BARE GROUND
TOTAL = 0.1234 SQ. IN

0.75" EMT CONDUIT IS ADEQUATE TO HANDLE THE TOTAL OF (3) WIRES, INCLUDING GROUND WIRE, AS INDICATED ABOVE.

PPC FEED CONDUCTORS (1 CONDUIT): USING THWN, CU.
 3/0 - 0.2679 SQ. IN X 3 = 0.8037 SQ. IN
 #6 - 0.0507 SQ. IN X 1 = 0.0507 SQ. IN <GROUND
TOTAL = 0.8544 SQ. IN

3.0" SCH 40 PVC CONDUIT IS ADEQUATE TO HANDLE THE TOTAL OF (4) WIRES, INCLUDING GROUND WIRE, AS INDICATED ABOVE.



5701 SOUTH SANTA FE DRIVE
LITTLETON, CO 80120



2840 HOWE ROAD, SUITE E
MARTINEZ, CA 94553
www.TheCBRGroup.com

IT IS A VIOLATION OF LAW FOR ANY PERSON, UNLESS THEY ARE ACTING UNDER THE DIRECTION OF A LICENSED PROFESSIONAL ENGINEER, TO ALTER THIS DOCUMENT.

DRAWN BY: CHECKED BY: APPROVED BY:
MST --- ---
RFDS REV #: 2 02/09/2022

CONSTRUCTION DOCUMENTS

SUBMITTALS		
REV	DATE	DESCRIPTION
A	06/14/2022	90% CD'S ISSUED FOR REVIEW

A&E PROJECT NUMBER
SFSF000580A

DISH Wireless L.L.C.
PROJECT INFORMATION
SFSF000580A
100 FOUNTAIN GROVE PKWY
SANTA ROSA, CA 95403

SHEET TITLE
ELECTRICAL ONE-LINE, FAULT
CALCS & PANEL SCHEDULE

SHEET NUMBER
E-3

PPC ONE-LINE DIAGRAM

NO SCALE 1


PROPOSED CHARLES PANEL SCHEDULE										
LOAD SERVED	VOLT AMPS (WATTS)		TRIP	CKT #	PHASE	CKT #	TRIP	VOLT AMPS (WATTS)		LOAD SERVED
	L1	L2						L1	L2	
PPC GFCI OUTLET	180	180	15A	1	A	2	30A	2880	2880	ABB/GE INFINITY RECTIFIER 1
CHARLES GFCI OUTLET	180	180	15A	3	B	4	30A	2880	2880	ABB/GE INFINITY RECTIFIER 1
-SPACE-				5	A	6	30A	2880	2880	ABB/GE INFINITY RECTIFIER 2
-SPACE-				7	B	8	30A	2880	2880	ABB/GE INFINITY RECTIFIER 2
-SPACE-				9	A	10	30A	2880	2880	ABB/GE INFINITY RECTIFIER 3
-SPACE-				11	B	12	30A	2880	2880	ABB/GE INFINITY RECTIFIER 3
-SPACE-				13	A	14	30A	2880	2880	ABB/GE INFINITY RECTIFIER 4
-SPACE-				15	B	16	30A	2880	2880	ABB/GE INFINITY RECTIFIER 4
-SPACE-				17	A	18				-SPACE-
-SPACE-				19	B	20				-SPACE-
-SPACE-				21	A	22				-SPACE-
-SPACE-				23	B	24				-SPACE-
VOLTAGE AMPS		180	180					11520	11520	
200A MCB, 1φ, 24 SPACE, 120/208V				L1	L2					
MB RATING: 65,000 AIC				11700	11700					VOLTAGE AMPS
				56.25	56.25					AMPS
										112.5
										140.63
										MAX AMPS
										MAX 125%

PANEL SCHEDULE


NO SCALE 2

NOT USED

NO SCALE 3

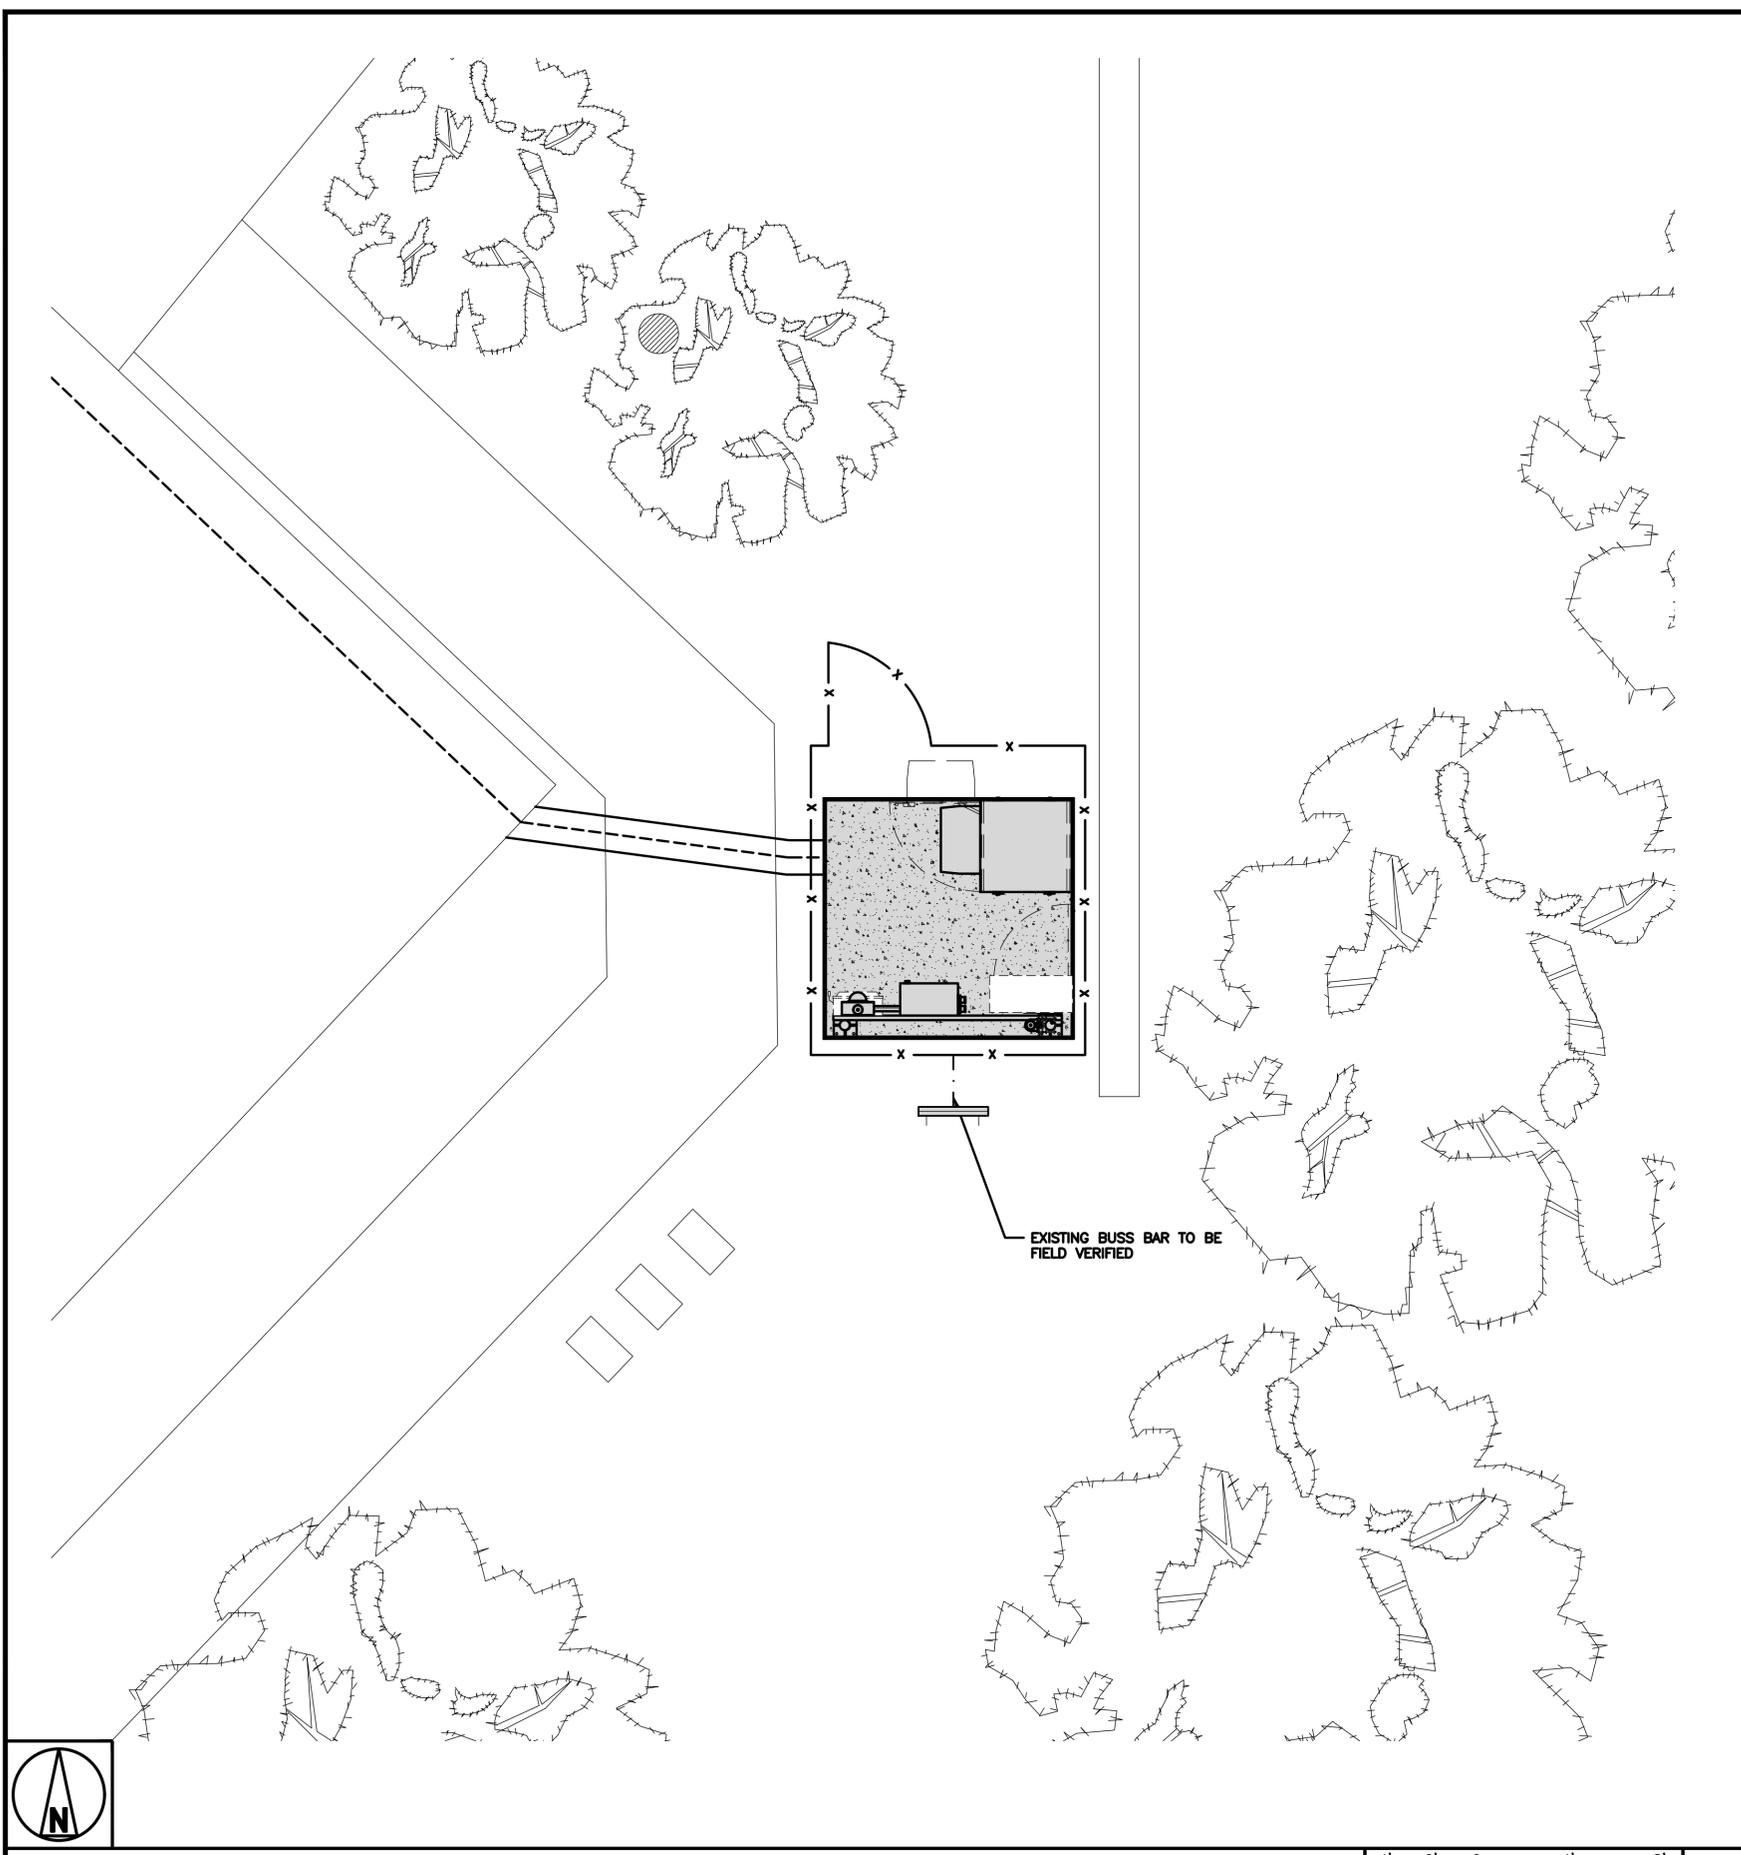

GROUNDING PLAN

 

1

- EXOTHERMIC CONNECTION
- MECHANICAL CONNECTION
- ▬ GROUND BUS BAR
- GROUND ROD
- T TEST GROUND ROD WITH INSPECTION SLEEVE
- #6 AWG STRANDED & INSULATED
- - - - - #2 AWG SOLID COPPER TINNED
- ▲ BUSS BAR INSULATOR

GROUNDING LEGEND

1. GROUNDING IS SHOWN DIAGRAMMATICALLY ONLY.
2. CONTRACTOR SHALL GROUND ALL EQUIPMENT AS A COMPLETE SYSTEM. GROUNDING SHALL BE IN COMPLIANCE WITH NEC SECTION 250 AND DISH Wireless L.L.C. GROUNDING AND BONDING REQUIREMENTS AND MANUFACTURER'S SPECIFICATIONS.
3. ALL GROUND CONDUCTORS SHALL BE COPPER; NO ALUMINUM CONDUCTORS SHALL BE USED.
4. NO EXOTHERMIC WELDING ON ROOFTOP

GROUNDING ROOFTOP KEY NOTES

- (A) **EXTERIOR GROUND RING:** #2 AWG SOLID COPPER, BURIED AT A DEPTH OF AT LEAST 30 INCHES BELOW GRADE, OR 6 INCHES BELOW THE FROST LINE AND APPROXIMATELY 24 INCHES FROM THE EXTERIOR WALL OR FOOTING.
- (B) **ROOFTOP GROUND SYSTEM:** THE GROUND SYSTEM USING MINIMUM #2 AWG SOLID COPPER CONDUCTORS.
- (C) **INTERIOR GROUND RING:** #2 AWG STRANDED GREEN INSULATED COPPER CONDUCTOR EXTENDED AROUND THE PERIMETER OF THE EQUIPMENT AREA. ALL NON-TELECOMMUNICATIONS RELATED METALLIC OBJECTS FOUND WITHIN A SITE SHALL BE GROUNDED TO THE INTERIOR GROUND RING WITH #6 AWG STRANDED GREEN INSULATED CONDUCTOR.
- (D) **BOND TO INTERIOR GROUND RING:** #2 AWG SOLID TINNED COPPER WIRE PRIMARY BONDS SHALL BE PROVIDED AT LEAST AT FOUR POINTS ON THE INTERIOR GROUND RING, LOCATED AT THE CORNERS OF THE BUILDING OR ROOM.
- (E) **GROUND ROD:** UL LISTED COPPER CLAD STEEL. MINIMUM 1/2" DIAMETER BY EIGHT FEET LONG. GROUND RODS SHALL BE INSTALLED WITH INSPECTION SLEEVES. GROUND RODS SHALL BE DRIVEN TO THE DEPTH OF GROUND RING CONDUCTOR.
- (F) **CELL REFERENCE GROUND BAR (CRGB):** POINT OF GROUND REFERENCE FOR ALL COMMUNICATIONS EQUIPMENT FRAMES. ALL BONDS ARE MADE WITH #2 AWG UNLESS NOTED OTHERWISE STRANDED GREEN INSULATED COPPER CONDUCTORS. BOND TO COMMON BUILDING GROUND SYSTEM WITH (2) #2 SOLID TINNED COPPER CONDUCTORS.
- (G) **HATCH PLATE GROUND BAR:** BOND TO THE COMMON BUILDING GROUND SYSTEM WITH TWO #2 AWG STRANDED GREEN INSULATED COPPER CONDUCTORS. WHEN A HATCH-PLATE AND A CELL REFERENCE GROUND BAR ARE BOTH PRESENT, THE CRGB MUST BE CONNECTED TO THE HATCH-PLATE AND TO THE INTERIOR GROUND RING USING (2) TWO #2 AWG STRANDED GREEN INSULATED COPPER CONDUCTORS EACH.
- (H) **EXTERIOR CABLE ENTRY PORT GROUND BARS:** LOCATED AT THE ENTRANCE TO THE CELL SITE ROOM. BOND TO GROUND RING WITH A #2 AWG SOLID TINNED COPPER CONDUCTORS WITH MECHANICAL CONNECTIONS.
- (I) **TELCO GROUND BAR:** BOND TO BOTH CELL REFERENCE GROUND BAR OR EXTERIOR GROUND RING.
- (J) **FRAME BONDING:** THE BONDING POINT FOR TELECOM EQUIPMENT FRAMES SHALL BE THE GROUND BUS THAT IS NOT ISOLATED FROM THE EQUIPMENTS METAL FRAMEWORK.
- (K) **INTERIOR UNIT BONDS:** METAL FRAMES, CABINETS AND INDIVIDUAL METALLIC UNITS LOCATED WITH THE AREA OF THE INTERIOR GROUND RING REQUIRE A #6 AWG STRANDED GREEN INSULATED COPPER BOND TO THE INTERIOR GROUND RING.
- (L) **FENCE AND GATE GROUNDING:** METAL FENCES SHALL BE BONDED TO THE COMMON BUILDING GROUND SYSTEM WITH A #2 AWG SOLID TINNED COPPER CONDUCTOR AT AN INTERVAL NOT EXCEEDING 25 FEET. BONDS SHALL BE MADE AT EACH GATE POST AND ACROSS GATE OPENINGS.
- (M) **EXTERIOR UNIT BONDS:** METALLIC OBJECTS, EXTERNAL TO OR MOUNTED TO THE BUILDING, SHALL BE BONDED TO THE COMMON BUILDING GROUND SYSTEM. USING #2 TINNED SOLID COPPER WIRE
- (N) **ICE BRIDGE SUPPORTS:** EACH ICE BRIDGE LEG SHALL BE BONDED TO THE GROUND RING WITH #2 AWG BARE TINNED COPPER CONDUCTOR. PROVIDE EXOTHERMIC WELDS AT BOTH THE ICE BRIDGE LEG AND BURIED GROUND RING.
- (O) **DURING ALL DC POWER SYSTEM CHANGES INCLUDING DC SYSTEM CHANGE OUTS, RECTIFIER REPLACEMENTS OR ADDITIONS, BREAKER DISTRIBUTION CHANGES, BATTERY ADDITIONS, BATTERY REPLACEMENTS AND INSTALLATIONS OR CHANGES TO DC CONVERTER SYSTEMS IT SHALL BE REQUIRED THAT SERVICE CONTRACTORS VERIFY ALL DC POWER SYSTEMS ARE EQUIPPED WITH A MASTER DC SYSTEM RETURN GROUND CONDUCTOR FROM THE DC POWER SYSTEM COMMON RETURN BUS DIRECTLY CONNECTED TO THE CELL SITE REFERENCE GROUND BAR**
- (P) **ROOFTOP COLLECTOR BUSS BAR IS TO BE MECHANICALLY BONDED TO COMMON BUILDING GROUND SYSTEM. REFER TO DISH Wireless L.L.C. GROUNDING NOTES.**

GROUNDING KEY NOTES

NO SCALE

2



5701 SOUTH SANTA FE DRIVE
LITTLETON, CO 80120



2840 HOWE ROAD, SUITE E
MARTINEZ, CA 94553
www.TheCBRGroup.com

IT IS A VIOLATION OF LAW FOR ANY PERSON, UNLESS THEY ARE ACTING UNDER THE DIRECTION OF A LICENSED PROFESSIONAL ENGINEER, TO ALTER THIS DOCUMENT.

DRAWN BY:	CHECKED BY:	APPROVED BY:
MST	---	---

RFDS REV #: 2 02/09/2022

CONSTRUCTION DOCUMENTS


SUBMITTALS		
REV	DATE	DESCRIPTION
A	06/14/2022	90% CD'S ISSUED FOR REVIEW

A&E PROJECT NUMBER
SFSF000580A

DISH Wireless L.L.C.
PROJECT INFORMATION
SFSF000580A
100 FOUNTAIN GROVE PKWY
SANTA ROSA, CA 95403


SHEET TITLE
GROUNDING PLANS AND NOTES

SHEET NUMBER
G-1

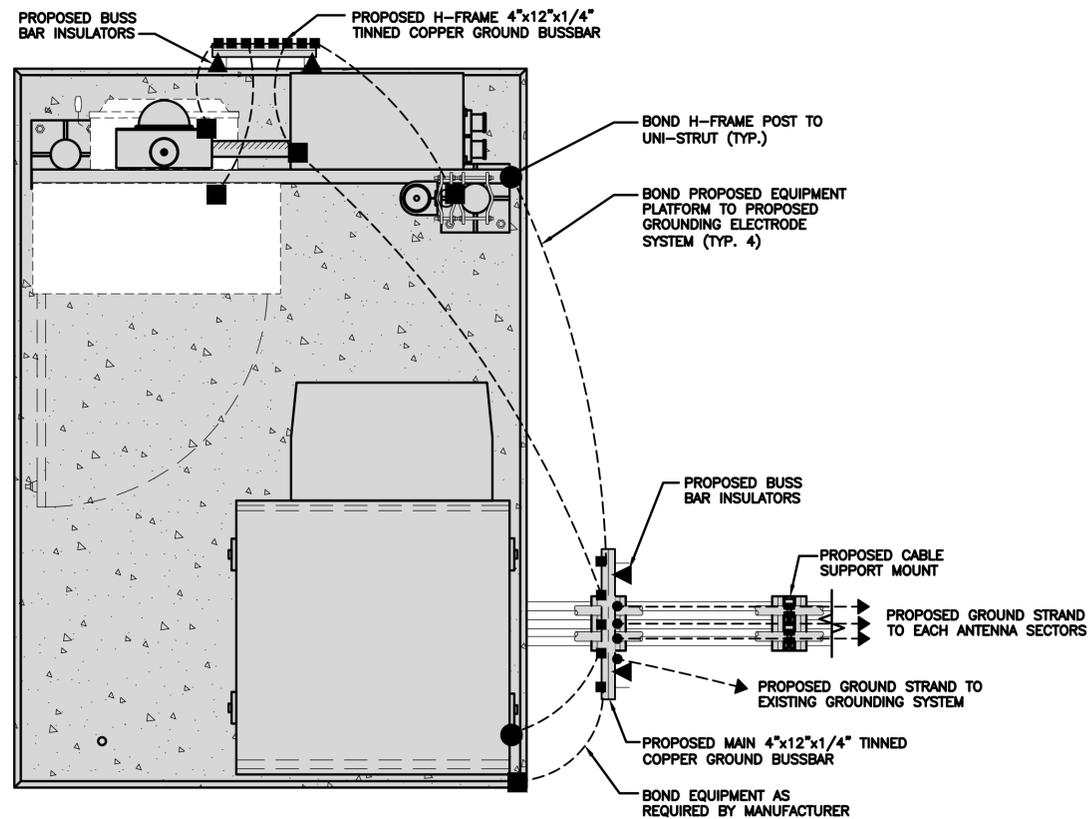

TYPICAL ROOFTOP EQUIPMENT GROUNDING PLAN

NO SCALE 1

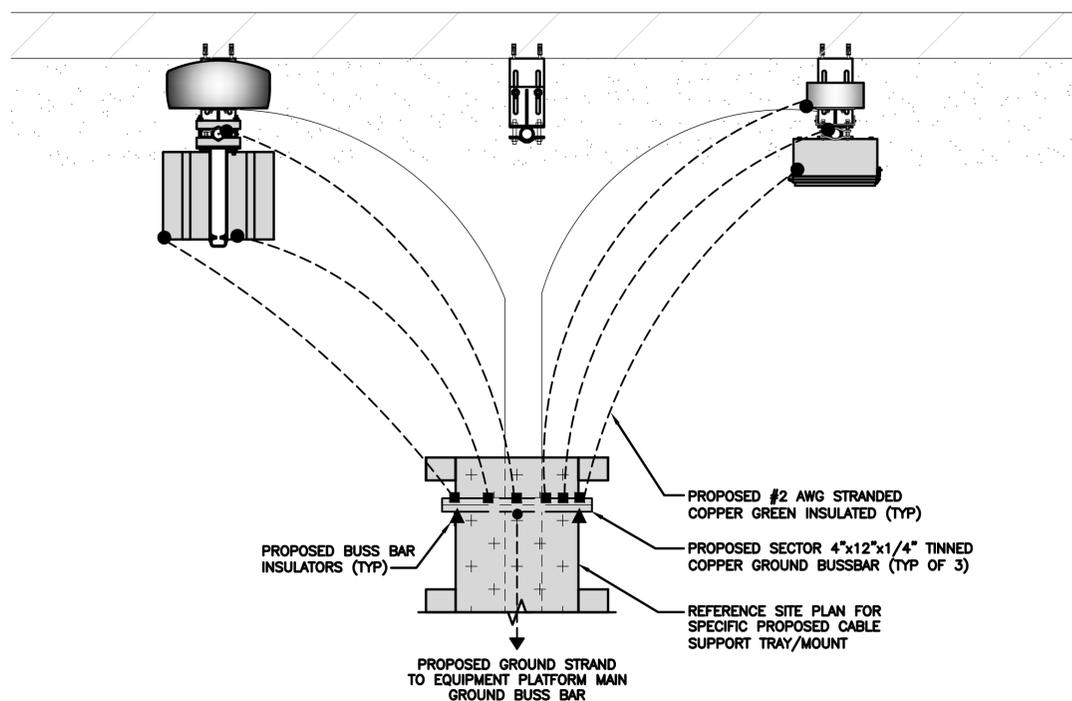


TYPICAL ROOFTOP ANTENNA GROUNDING PLAN

NO SCALE 2

NOTE

EQUIPMENT CABINET OMITTED FOR CLARITY

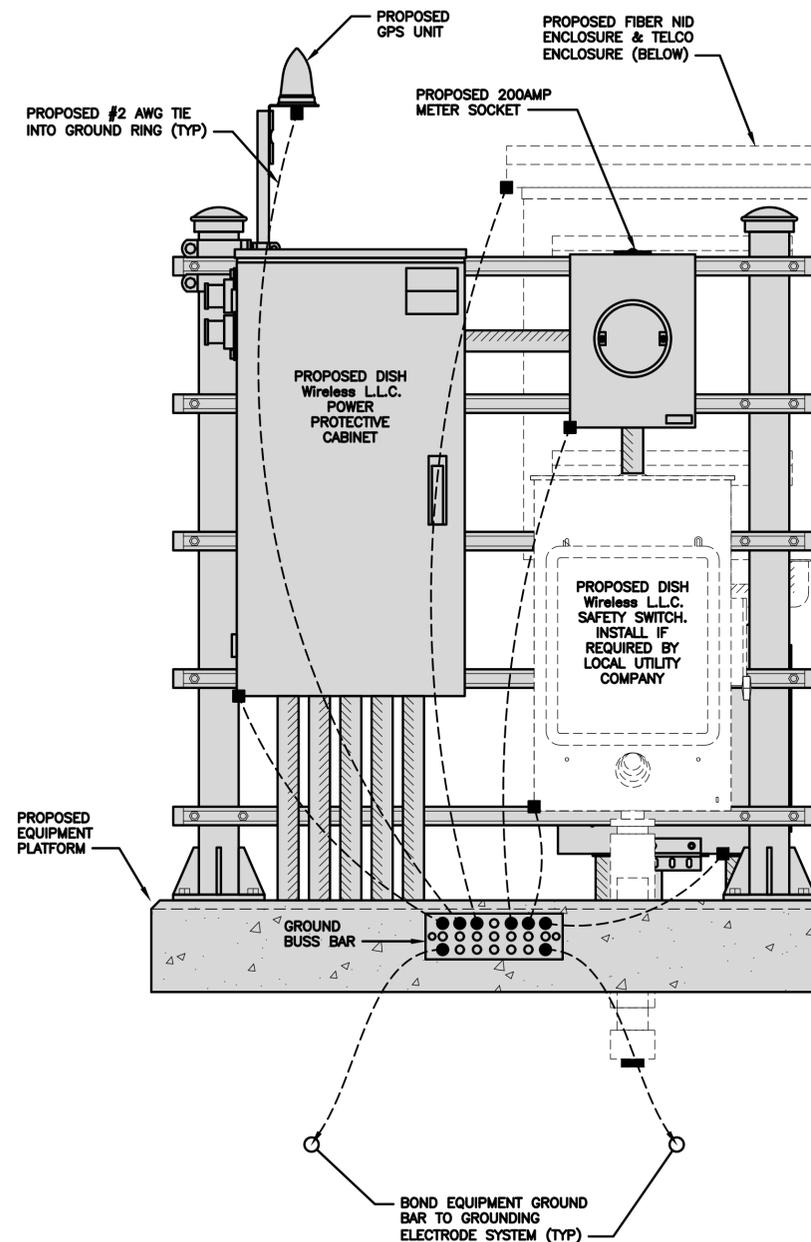

H-FRAME GROUNDING DETAIL

NO SCALE 3



5701 SOUTH SANTA FE DRIVE
LITTLETON, CO 80120



2840 HOWE ROAD, SUITE E
MARTINEZ, CA 94553
www.TheCBRGroup.com

IT IS A VIOLATION OF LAW FOR ANY PERSON, UNLESS THEY ARE ACTING UNDER THE DIRECTION OF A LICENSED PROFESSIONAL ENGINEER, TO ALTER THIS DOCUMENT.

DRAWN BY: CHECKED BY: APPROVED BY:
MST --- ---

RFDS REV #: 2 02/09/2022

CONSTRUCTION DOCUMENTS

SUBMITTALS		
REV	DATE	DESCRIPTION
A	06/14/2022	90% CD'S ISSUED FOR REVIEW



A&E PROJECT NUMBER
SFSF000580A

DISH Wireless L.L.C.
PROJECT INFORMATION
SFSF000580A
100 FOUNTAIN GROVE PKWY
SANTA ROSA, CA 95403

SHEET TITLE
GROUNDING DETAILS

SHEET NUMBER
G-2

1. EXOTHERMIC WELD (2) TWO, #2 AWG BARE TINNED SOLID COPPER CONDUCTORS TO GROUND BAR. ROUTE CONDUCTORS TO BURIED GROUND RING AND PROVIDE PARALLEL EXOTHERMIC WELD.
2. ALL EXTERIOR GROUNDING HARDWARE SHALL BE STAINLESS STEEL 3/8" DIAMETER OR LARGER. ALL HARDWARE 18-8 STAINLESS STEEL INCLUDING LOCK WASHERS, COAT ALL SURFACES WITH AN ANTI-OXIDANT COMPOUND BEFORE MATING.
3. FOR GROUND BOND TO STEEL ONLY: COAT ALL SURFACES WITH AN ANTI-OXIDANT COMPOUND BEFORE MATING.
4. DO NOT INSTALL CABLE GROUNDING KIT AT A BEND AND ALWAYS DIRECT GROUND CONDUCTOR DOWN TO GROUNDING BUS.
5. NUT & WASHER SHALL BE PLACED ON THE FRONT SIDE OF THE GROUND BAR AND BOLTED ON THE BACK SIDE.
6. ALL GROUNDING PARTS AND EQUIPMENT TO BE SUPPLIED AND INSTALLED BY CONTRACTOR.
7. THE CONTRACTOR SHALL BE RESPONSIBLE FOR INSTALLING ADDITIONAL GROUND BAR AS REQUIRED.
8. ENSURE THE WIRE INSULATION TERMINATION IS WITHIN 1/8" OF THE BARREL (NO SHINERS).

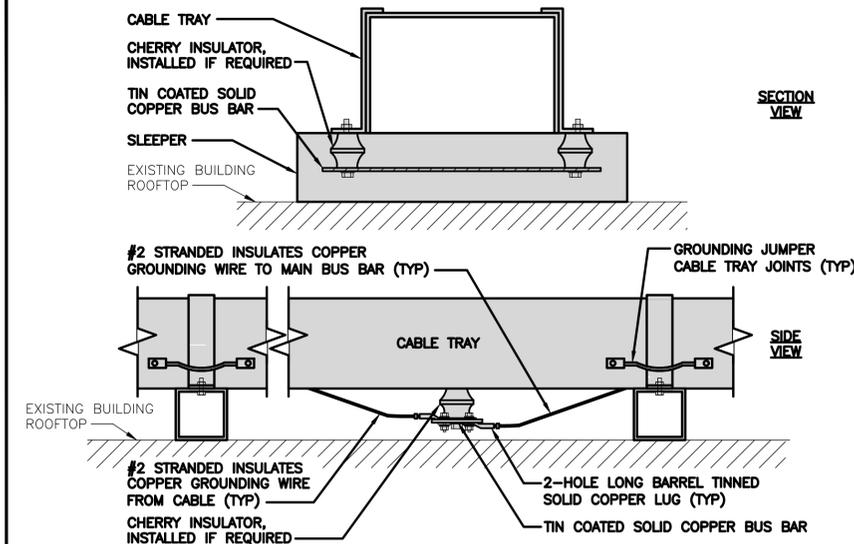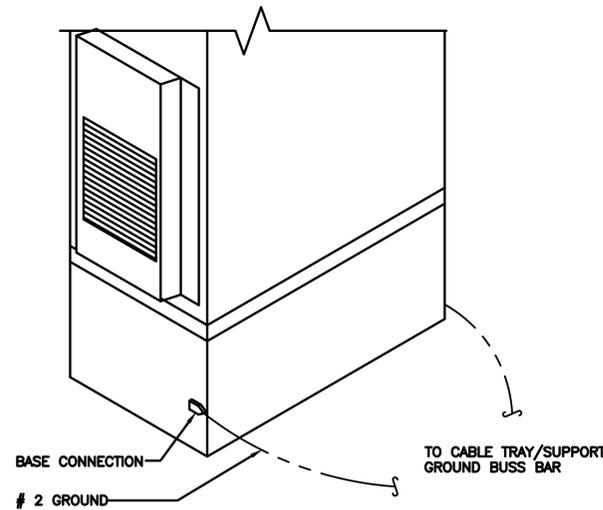

TYPICAL GROUNDING NOTES


NO SCALE 1

OUTDOOR CABINET GROUNDING

NO SCALE 2


TYPICAL CABLE TRAY GROUND BUSS BAR

NO SCALE 3

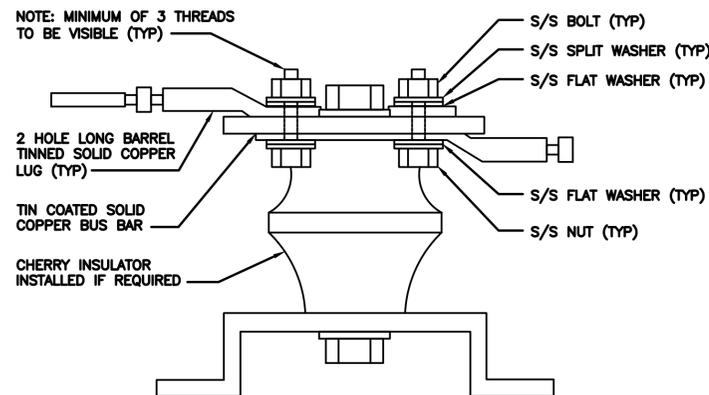


LUG DETAIL

NO SCALE 4

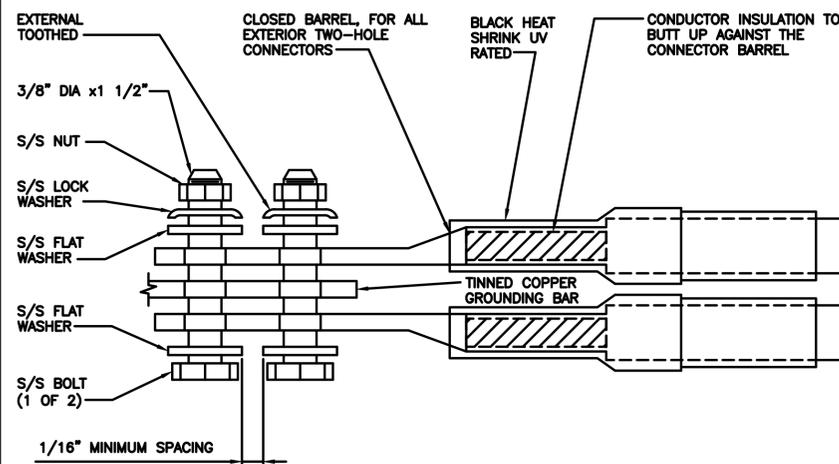

TYPICAL EXTERIOR TWO HOLE LUG

NO SCALE 5

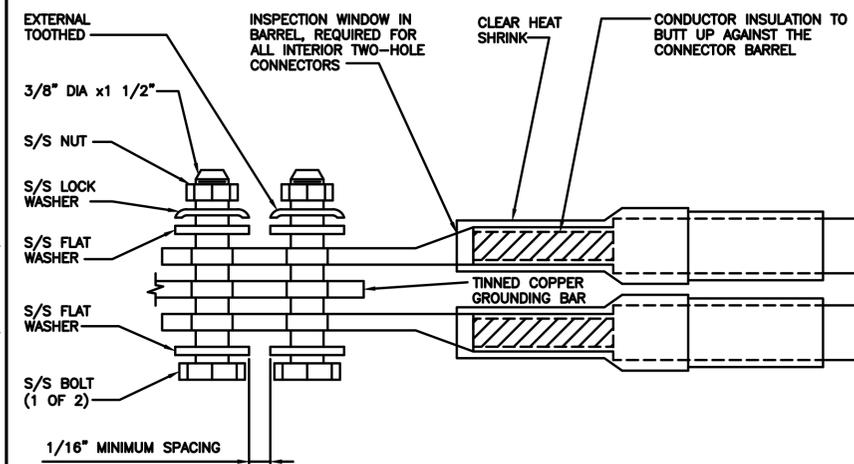

TYPICAL INTERIOR TWO HOLE LUG

NO SCALE 6

NOT USED

NO SCALE 7

NOT USED

NO SCALE 8

NOT USED

NO SCALE 9

dish
wireless.

5701 SOUTH SANTA FE DRIVE
LITTLETON, CO 80120

THE
CBR
GROUP

2840 HOWE ROAD, SUITE E
MARTINEZ, CA 94553
www.TheCBRGroup.com

IT IS A VIOLATION OF LAW FOR ANY PERSON, UNLESS THEY ARE ACTING UNDER THE DIRECTION OF A LICENSED PROFESSIONAL ENGINEER, TO ALTER THIS DOCUMENT.

DRAWN BY: CHECKED BY: APPROVED BY:

MST --- ---

RFDS REV #: 2 02/09/2022

CONSTRUCTION DOCUMENTS

SUBMITTALS		
REV	DATE	DESCRIPTION
A	06/14/2022	90% CD'S ISSUED FOR REVIEW

A&E PROJECT NUMBER
SFSF000580A

DISH Wireless L.L.C.
PROJECT INFORMATION
SFSF000580A
100 FOUNTAIN GROVE PKWY
SANTA ROSA, CA 95403

SHEET TITLE
GROUNDING DETAILS

SHEET NUMBER
G-3

HYBRID/DISCREET CABLES												3/4" TAPE WIDTHS WITH 3/4" SPACING																																																																							
<p>LOW-BAND RRH (600 MHz N71 BASEBAND) + (850 MHz N26 BAND) + (700 MHz N29 BAND) - OPTIONAL PER MARKET</p> <p>ADD FREQUENCY COLOR TO SECTOR BAND (CBRS WILL USE YELLOW BAND)</p>												<p>ALPHA RRH</p> <table border="1"> <tr><th>PORT 1 + SLANT</th><th>PORT 2 - SLANT</th><th>PORT 3 + SLANT</th><th>PORT 4 - SLANT</th></tr> <tr><td>RED</td><td>RED</td><td>RED</td><td>RED</td></tr> <tr><td>ORANGE</td><td>ORANGE</td><td>RED</td><td>RED</td></tr> <tr><td></td><td>WHITE (-) PORT</td><td>ORANGE</td><td>ORANGE</td></tr> <tr><td></td><td></td><td>WHITE (-) PORT</td><td>WHITE (-) PORT</td></tr> </table>				PORT 1 + SLANT	PORT 2 - SLANT	PORT 3 + SLANT	PORT 4 - SLANT	RED	RED	RED	RED	ORANGE	ORANGE	RED	RED		WHITE (-) PORT	ORANGE	ORANGE			WHITE (-) PORT	WHITE (-) PORT	<p>BETA RRH</p> <table border="1"> <tr><th>PORT 1 + SLANT</th><th>PORT 2 - SLANT</th><th>PORT 3 + SLANT</th><th>PORT 4 - SLANT</th></tr> <tr><td>BLUE</td><td>BLUE</td><td>BLUE</td><td>BLUE</td></tr> <tr><td>ORANGE</td><td>ORANGE</td><td>BLUE</td><td>BLUE</td></tr> <tr><td></td><td>WHITE (-) PORT</td><td>ORANGE</td><td>ORANGE</td></tr> <tr><td></td><td></td><td>WHITE (-) PORT</td><td>WHITE (-) PORT</td></tr> </table>				PORT 1 + SLANT	PORT 2 - SLANT	PORT 3 + SLANT	PORT 4 - SLANT	BLUE	BLUE	BLUE	BLUE	ORANGE	ORANGE	BLUE	BLUE		WHITE (-) PORT	ORANGE	ORANGE			WHITE (-) PORT	WHITE (-) PORT	<p>GAMMA RRH</p> <table border="1"> <tr><th>PORT 1 + SLANT</th><th>PORT 2 - SLANT</th><th>PORT 3 + SLANT</th><th>PORT 4 - SLANT</th></tr> <tr><td>GREEN</td><td>GREEN</td><td>GREEN</td><td>GREEN</td></tr> <tr><td>ORANGE</td><td>ORANGE</td><td>GREEN</td><td>GREEN</td></tr> <tr><td></td><td>WHITE (-) PORT</td><td>ORANGE</td><td>ORANGE</td></tr> <tr><td></td><td></td><td>WHITE (-) PORT</td><td>WHITE (-) PORT</td></tr> </table>				PORT 1 + SLANT	PORT 2 - SLANT	PORT 3 + SLANT	PORT 4 - SLANT	GREEN	GREEN	GREEN	GREEN	ORANGE	ORANGE	GREEN	GREEN		WHITE (-) PORT	ORANGE	ORANGE			WHITE (-) PORT	WHITE (-) PORT
PORT 1 + SLANT	PORT 2 - SLANT	PORT 3 + SLANT	PORT 4 - SLANT																																																																																
RED	RED	RED	RED																																																																																
ORANGE	ORANGE	RED	RED																																																																																
	WHITE (-) PORT	ORANGE	ORANGE																																																																																
		WHITE (-) PORT	WHITE (-) PORT																																																																																
PORT 1 + SLANT	PORT 2 - SLANT	PORT 3 + SLANT	PORT 4 - SLANT																																																																																
BLUE	BLUE	BLUE	BLUE																																																																																
ORANGE	ORANGE	BLUE	BLUE																																																																																
	WHITE (-) PORT	ORANGE	ORANGE																																																																																
		WHITE (-) PORT	WHITE (-) PORT																																																																																
PORT 1 + SLANT	PORT 2 - SLANT	PORT 3 + SLANT	PORT 4 - SLANT																																																																																
GREEN	GREEN	GREEN	GREEN																																																																																
ORANGE	ORANGE	GREEN	GREEN																																																																																
	WHITE (-) PORT	ORANGE	ORANGE																																																																																
		WHITE (-) PORT	WHITE (-) PORT																																																																																
<p>MID-BAND RRH (AWS BANDS N66+N70)</p> <p>ADD FREQUENCY COLOR TO SECTOR BAND (CBRS WILL USE YELLOW BANDS)</p>												<table border="1"> <tr><td>RED</td><td>RED</td><td>RED</td><td>RED</td><td>BLUE</td><td>BLUE</td><td>BLUE</td><td>BLUE</td><td>GREEN</td><td>GREEN</td><td>GREEN</td><td>GREEN</td></tr> <tr><td>PURPLE</td><td>PURPLE</td><td>RED</td><td>RED</td><td>PURPLE</td><td>PURPLE</td><td>BLUE</td><td>BLUE</td><td>PURPLE</td><td>PURPLE</td><td>GREEN</td><td>GREEN</td></tr> <tr><td></td><td>WHITE (-) PORT</td><td>PURPLE</td><td>PURPLE</td><td></td><td>WHITE (-) PORT</td><td>PURPLE</td><td>PURPLE</td><td></td><td>WHITE (-) PORT</td><td>PURPLE</td><td>PURPLE</td></tr> <tr><td></td><td></td><td></td><td>WHITE (-) PORT</td><td></td><td></td><td></td><td>WHITE (-) PORT</td><td></td><td></td><td></td><td>WHITE (-) PORT</td></tr> </table>				RED	RED	RED	RED	BLUE	BLUE	BLUE	BLUE	GREEN	GREEN	GREEN	GREEN	PURPLE	PURPLE	RED	RED	PURPLE	PURPLE	BLUE	BLUE	PURPLE	PURPLE	GREEN	GREEN		WHITE (-) PORT	PURPLE	PURPLE		WHITE (-) PORT	PURPLE	PURPLE		WHITE (-) PORT	PURPLE	PURPLE				WHITE (-) PORT				WHITE (-) PORT				WHITE (-) PORT																				
RED	RED	RED	RED	BLUE	BLUE	BLUE	BLUE	GREEN	GREEN	GREEN	GREEN																																																																								
PURPLE	PURPLE	RED	RED	PURPLE	PURPLE	BLUE	BLUE	PURPLE	PURPLE	GREEN	GREEN																																																																								
	WHITE (-) PORT	PURPLE	PURPLE		WHITE (-) PORT	PURPLE	PURPLE		WHITE (-) PORT	PURPLE	PURPLE																																																																								
			WHITE (-) PORT				WHITE (-) PORT				WHITE (-) PORT																																																																								
<p>HYBRID/DISCREET CABLES</p> <p>INCLUDE SECTOR BANDS BEING SUPPORTED ALONG WITH FREQUENCY BANDS.</p> <p>EXAMPLE 1 - HYBRID, OR DISCREET, SUPPORTS ALL SECTORS, BOTH LOW-BANDS AND MID-BANDS.</p> <p>EXAMPLE 2 - HYBRID, OR DISCREET, SUPPORTS CBRS ONLY, ALL SECTORS.</p> <p>EXAMPLE 3 - MAIN COAX WITH GROUND MOUNTED RRHS.</p>												<p>EXAMPLE 1</p> <table border="1"> <tr><td>RED</td><td>BLUE</td><td>GREEN</td><td>ORANGE</td><td>PURPLE</td></tr> </table>		RED	BLUE	GREEN	ORANGE	PURPLE	<p>EXAMPLE 2</p> <table border="1"> <tr><td>RED</td><td>BLUE</td><td>GREEN</td><td>YELLOW</td></tr> </table>		RED	BLUE	GREEN	YELLOW	<p>EXAMPLE 3 COAX #1 (ALPHA)</p> <table border="1"> <tr><td>RED</td></tr> </table>		RED	<p>EXAMPLE 3 COAX #2 (ALPHA)</p> <table border="1"> <tr><td>RED</td></tr> </table>		RED																																																					
RED	BLUE	GREEN	ORANGE	PURPLE																																																																															
RED	BLUE	GREEN	YELLOW																																																																																
RED																																																																																			
RED																																																																																			
<p>FIBER JUMPERS TO RRHS</p> <p>LOW-BAND HHR FIBER CABLES HAVE SECTOR STRIPE ONLY.</p>												<p>LOW BAND RRH</p> <table border="1"> <tr><td>RED</td><td>ORANGE</td></tr> </table>		RED	ORANGE	<p>MID BAND RRH</p> <table border="1"> <tr><td>RED</td><td>PURPLE</td></tr> </table>		RED	PURPLE	<p>LOW BAND RRH</p> <table border="1"> <tr><td>BLUE</td><td>ORANGE</td></tr> </table>		BLUE	ORANGE	<p>MID BAND RRH</p> <table border="1"> <tr><td>BLUE</td><td>PURPLE</td></tr> </table>		BLUE	PURPLE	<p>LOW BAND RRH</p> <table border="1"> <tr><td>GREEN</td><td>ORANGE</td></tr> </table>		GREEN	ORANGE	<p>MID BAND RRH</p> <table border="1"> <tr><td>GREEN</td><td>PURPLE</td></tr> </table>		GREEN	PURPLE																																																
RED	ORANGE																																																																																		
RED	PURPLE																																																																																		
BLUE	ORANGE																																																																																		
BLUE	PURPLE																																																																																		
GREEN	ORANGE																																																																																		
GREEN	PURPLE																																																																																		
<p>POWER CABLES TO RRHS</p> <p>LOW-BAND RRH POWER CABLES HAVE SECTOR STRIPE ONLY.</p>												<p>LOW BAND RRH</p> <table border="1"> <tr><td>RED</td><td>ORANGE</td></tr> </table>		RED	ORANGE	<p>MID BAND RRH</p> <table border="1"> <tr><td>RED</td><td>PURPLE</td></tr> </table>		RED	PURPLE	<p>LOW BAND RRH</p> <table border="1"> <tr><td>BLUE</td><td>ORANGE</td></tr> </table>		BLUE	ORANGE	<p>MID BAND RRH</p> <table border="1"> <tr><td>BLUE</td><td>PURPLE</td></tr> </table>		BLUE	PURPLE	<p>LOW BAND RRH</p> <table border="1"> <tr><td>GREEN</td><td>ORANGE</td></tr> </table>		GREEN	ORANGE	<p>MID BAND RRH</p> <table border="1"> <tr><td>GREEN</td><td>PURPLE</td></tr> </table>		GREEN	PURPLE																																																
RED	ORANGE																																																																																		
RED	PURPLE																																																																																		
BLUE	ORANGE																																																																																		
BLUE	PURPLE																																																																																		
GREEN	ORANGE																																																																																		
GREEN	PURPLE																																																																																		
<p>RET MOTORS AT ANTENNAS</p> <p>RET CONTROL IS HANDLED BY THE MID-BAND RRH WHEN ONE SET OF RET PORTS EXIST ON ANTENNA.</p> <p>SEPARATE RET CABLES ARE USED WHEN ANTENNA PORTS PROVIDE INPUTS FOR BOTH LOW AND MID BANDS.</p>												<p>ANTENNA 1 MID BAND</p> <table border="1"> <tr><th>IN</th><th>IN</th></tr> <tr><td>RED</td><td>RED</td></tr> <tr><td>PURPLE</td><td>ORANGE</td></tr> </table>		IN	IN	RED	RED	PURPLE	ORANGE	<p>ANTENNA 1 MID BAND</p> <table border="1"> <tr><th>IN</th><th>IN</th></tr> <tr><td>BLUE</td><td>BLUE</td></tr> <tr><td>PURPLE</td><td>ORANGE</td></tr> </table>		IN	IN	BLUE	BLUE	PURPLE	ORANGE	<p>ANTENNA 1 MID BAND</p> <table border="1"> <tr><th>IN</th><th>IN</th></tr> <tr><td>GREEN</td><td>GREEN</td></tr> <tr><td>PURPLE</td><td>ORANGE</td></tr> </table>		IN	IN	GREEN	GREEN	PURPLE	ORANGE																																																
IN	IN																																																																																		
RED	RED																																																																																		
PURPLE	ORANGE																																																																																		
IN	IN																																																																																		
BLUE	BLUE																																																																																		
PURPLE	ORANGE																																																																																		
IN	IN																																																																																		
GREEN	GREEN																																																																																		
PURPLE	ORANGE																																																																																		
<p>MICROWAVE RADIO LINKS</p> <p>LINKS WILL HAVE A 1.5-2 INCH WHITE WRAP WITH THE AZIMUTH COLOR OVERLAPPING IN THE MIDDLE.</p> <p>ADD ADDITIONAL SECTOR COLOR BANDS FOR EACH ADDITIONAL MW RADIO.</p> <p>MICROWAVE CABLES WILL REQUIRE P-TOUCH LABELS INSIDE THE CABINET TO IDENTIFY THE LOCAL AND REMOTE SITE ID'S.</p>												<p>FORWARD AZIMUTH OF 0-120 DEGREES</p> <table border="1"> <tr><th>PRIMARY</th><th>SECONDARY</th></tr> <tr><td>WHITE</td><td>WHITE</td></tr> <tr><td>RED</td><td>RED</td></tr> <tr><td>WHITE</td><td>WHITE</td></tr> <tr><td></td><td>RED</td></tr> <tr><td></td><td>WHITE</td></tr> </table>		PRIMARY	SECONDARY	WHITE	WHITE	RED	RED	WHITE	WHITE		RED		WHITE	<p>FORWARD AZIMUTH OF 120-240 DEGREES</p> <table border="1"> <tr><th>PRIMARY</th><th>SECONDARY</th></tr> <tr><td>WHITE</td><td>WHITE</td></tr> <tr><td>BLUE</td><td>BLUE</td></tr> <tr><td>WHITE</td><td>WHITE</td></tr> <tr><td></td><td>BLUE</td></tr> <tr><td></td><td>WHITE</td></tr> </table>		PRIMARY	SECONDARY	WHITE	WHITE	BLUE	BLUE	WHITE	WHITE		BLUE		WHITE	<p>FORWARD AZIMUTH OF 240-359 DEGREES</p> <table border="1"> <tr><th>PRIMARY</th><th>SECONDARY</th></tr> <tr><td>WHITE</td><td>WHITE</td></tr> <tr><td>GREEN</td><td>GREEN</td></tr> <tr><td>WHITE</td><td>WHITE</td></tr> <tr><td></td><td>GREEN</td></tr> <tr><td></td><td>WHITE</td></tr> </table>		PRIMARY	SECONDARY	WHITE	WHITE	GREEN	GREEN	WHITE	WHITE		GREEN		WHITE																														
PRIMARY	SECONDARY																																																																																		
WHITE	WHITE																																																																																		
RED	RED																																																																																		
WHITE	WHITE																																																																																		
	RED																																																																																		
	WHITE																																																																																		
PRIMARY	SECONDARY																																																																																		
WHITE	WHITE																																																																																		
BLUE	BLUE																																																																																		
WHITE	WHITE																																																																																		
	BLUE																																																																																		
	WHITE																																																																																		
PRIMARY	SECONDARY																																																																																		
WHITE	WHITE																																																																																		
GREEN	GREEN																																																																																		
WHITE	WHITE																																																																																		
	GREEN																																																																																		
	WHITE																																																																																		

RF CABLE COLOR CODES

NO SCALE

1

NOT USED

NO SCALE

4

LOW BANDS (N71+N26) OPTIONAL - (N29)

ORANGE

AWS (N66+N70+H-BLOCK)

PURPLE

CBRS TECH (3 GHz)

YELLOW

NEGATIVE SLANT PORT ON ANT/RRH

WHITE

ALPHA SECTOR

RED

BETA SECTOR

BLUE

GAMMA SECTOR

GREEN

COLOR IDENTIFIER

NO SCALE

2

NOT USED

NO SCALE

3



5701 SOUTH SANTA FE DRIVE
LITTLETON, CO 80120



2840 HOWE ROAD, SUITE E
MARTINEZ, CA 94553
www.TheCBRGroup.com

IT IS A VIOLATION OF LAW FOR ANY PERSON, UNLESS THEY ARE ACTING UNDER THE DIRECTION OF A LICENSED PROFESSIONAL ENGINEER, TO ALTER THIS DOCUMENT.

DRAWN BY: CHECKED BY: APPROVED BY:

MST --- ---

RFDS REV #: 2 02/09/2022

CONSTRUCTION DOCUMENTS

SUBMITTALS

REV	DATE	DESCRIPTION
A	06/14/2022	90% CD'S ISSUED FOR REVIEW


 
A&E PROJECT NUMBER
SFSF000580A

DISH Wireless L.L.C.
PROJECT INFORMATION
SFSF000580A
100 FOUNTAIN GROVE PKWY
SANTA ROSA, CA 95403


SHEET TITLE
RF
CABLE COLOR CODE

SHEET NUMBER
RF-1

EXOTHERMIC CONNECTION
 MECHANICAL CONNECTION
 BUSS BAR INSULATOR
 CHEMICAL ELECTROLYTIC GROUNDING SYSTEM
 TEST CHEMICAL ELECTROLYTIC GROUNDING SYSTEM
 EXOTHERMIC WITH INSPECTION SLEEVE
 GROUNDING BAR
 GROUND ROD
 TEST GROUND ROD WITH INSPECTION SLEEVE
 SINGLE POLE SWITCH
 DUPLEX RECEPTACLE
 DUPLEX GFCI RECEPTACLE
 FLUORESCENT LIGHTING FIXTURE (2) TWO LAMPS 48-T8
 SMOKE DETECTION (DC)
 EMERGENCY LIGHTING (DC)
 SECURITY LIGHT W/PHOTOCELL LITHONIA ALXW
 LED-1-25A400/51K-SR4-120-PE-DOBTD
 CHAIN LINK FENCE
 WOOD/WROUGHT IRON FENCE
 WALL STRUCTURE
 LEASE AREA
 PROPERTY LINE (PL)
 SETBACKS
 ICE BRIDGE
 CABLE TRAY
 WATER LINE
 UNDERGROUND POWER
 UNDERGROUND TELCO
 OVERHEAD POWER
 OVERHEAD TELCO
 UNDERGROUND TELCO/POWER
 ABOVE GROUND POWER
 ABOVE GROUND TELCO
 ABOVE GROUND TELCO/POWER
 WORKPOINT

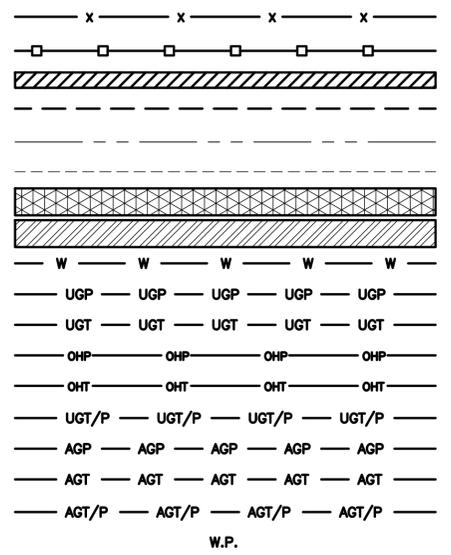

SECTION REFERENCE
 DETAIL REFERENCE

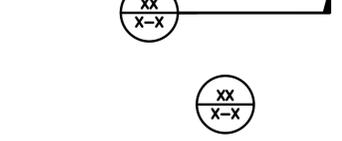

LEGEND

AB ANCHOR BOLT
 ABV ABOVE
 AC ALTERNATING CURRENT
 ADDL ADDITIONAL
 AFF ABOVE FINISHED FLOOR
 AFG ABOVE FINISHED GRADE
 AGL ABOVE GROUND LEVEL
 AIC AMPERAGE INTERRUPTION CAPACITY
 ALUM ALUMINUM
 ALT ALTERNATE
 ANT ANTENNA
 APPROX APPROXIMATE
 ARCH ARCHITECTURAL
 ATS AUTOMATIC TRANSFER SWITCH
 AWG AMERICAN WIRE GAUGE
 BATT BATTERY
 BLDG BUILDING
 BLK BLOCK
 BLKG BLOCKING
 BM BEAM
 BTC BARE TINNED COPPER CONDUCTOR
 BOF BOTTOM OF FOOTING
 CAB CABINET
 CANT CANTILEVERED
 CHG CHARGING
 CLG CEILING
 CLR CLEAR
 COL COLUMN
 COMM COMMON
 CONC CONCRETE
 CONSTR CONSTRUCTION
 DBL DOUBLE
 DC DIRECT CURRENT
 DEPT DEPARTMENT
 DF DOUGLAS FIR
 DIA DIAMETER
 DIAG DIAGONAL
 DIM DIMENSION
 DWG DRAWING
 DWL DOWEL
 EA EACH
 EC ELECTRICAL CONDUCTOR
 EL ELEVATION
 ELEC ELECTRICAL
 EMT ELECTRICAL METALLIC TUBING
 ENG ENGINEER
 EQ EQUAL
 EXP EXPANSION
 EXT EXTERIOR
 EW EACH WAY
 FAB FABRICATION
 FF FINISH FLOOR
 FG FINISH GRADE
 FIF FACILITY INTERFACE FRAME
 FIN FINISH(ED)
 FLR FLOOR
 FDN FOUNDATION
 FOC FACE OF CONCRETE
 FOM FACE OF MASONRY
 FOS FACE OF STUD
 FOW FACE OF WALL
 FS FINISH SURFACE
 FT FOOT
 FTG FOOTING
 GA GAUGE
 GEN GENERATOR
 GFCI GROUND FAULT CIRCUIT INTERRUPTER
 GLB GLUE LAMINATED BEAM
 GLV GALVANIZED
 GPS GLOBAL POSITIONING SYSTEM
 GND GROUND
 GSM GLOBAL SYSTEM FOR MOBILE
 HDG HOT DIPPED GALVANIZED
 HDR HEADER
 HGR HANGER
 HVAC HEAT/VENTILATION/AIR CONDITIONING
 HT HEIGHT
 IGR INTERIOR GROUND RING

IN INCH
 INT INTERIOR
 LB(S) POUND(S)
 LF LINEAR FEET
 LTE LONG TERM EVOLUTION
 MAS MASONRY
 MAX MAXIMUM
 MB MACHINE BOLT
 MECH MECHANICAL
 MFR MANUFACTURER
 MGB MASTER GROUND BAR
 MIN MINIMUM
 MISC MISCELLANEOUS
 MTL METAL
 MTS MANUAL TRANSFER SWITCH
 MW MICROWAVE
 NEC NATIONAL ELECTRIC CODE
 NM NEWTON METERS
 NO. NUMBER
 # NUMBER
 NTS NOT TO SCALE
 OC ON-CENTER
 OSHA OCCUPATIONAL SAFETY AND HEALTH ADMINISTRATION
 OPNG OPENING
 P/C PRECAST CONCRETE
 PCS PERSONAL COMMUNICATION SERVICES
 PCU PRIMARY CONTROL UNIT
 PRC PRIMARY RADIO CABINET
 PP POLARIZING PRESERVING
 PSF POUNDS PER SQUARE FOOT
 PSI POUNDS PER SQUARE INCH
 PT PRESSURE TREATED
 PWR POWER CABINET
 QTY QUANTITY
 RAD RADIUS
 RECT RECTIFIER
 REF REFERENCE
 REINF REINFORCEMENT
 REQ'D REQUIRED
 RET REMOTE ELECTRIC TILT
 RF RADIO FREQUENCY
 RMC RIGID METALLIC CONDUIT
 RRH REMOTE RADIO HEAD
 RRU REMOTE RADIO UNIT
 RWY RACEWAY
 SCH SCHEDULE
 SHT SHEET
 SIAD SMART INTEGRATED ACCESS DEVICE
 SIM SIMILAR
 SPEC SPECIFICATION
 SQ SQUARE
 SS STAINLESS STEEL
 STD STANDARD
 STL STEEL
 TEMP TEMPORARY
 THK THICKNESS
 TMA TOWER MOUNTED AMPLIFIER
 TN TOE NAIL
 TOA TOP OF ANTENNA
 TOC TOP OF CURB
 TOF TOP OF FOUNDATION
 TOP TOP OF PLATE (PARAPET)
 TOS TOP OF STEEL
 TOW TOP OF WALL
 TVSS TRANSIENT VOLTAGE SURGE SUPPRESSION
 TYP TYPICAL
 UG UNDERGROUND
 UL UNDERWRITERS LABORATORY
 UNO UNLESS NOTED OTHERWISE
 UMTS UNIVERSAL MOBILE TELECOMMUNICATIONS SYSTEM
 UPS UNINTERRUPTIBLE POWER SYSTEM (DC POWER PLANT)
 VIF VERIFIED IN FIELD
 W WIDE
 W/ WITH
 WD WOOD
 WP WEATHERPROOF
 WT WEIGHT

ABBREVIATIONS



5701 SOUTH SANTA FE DRIVE
 LITTLETON, CO 80120



2840 HOWE ROAD, SUITE E
 MARTINEZ, CA 94553
 www.TheCBRGroup.com

IT IS A VIOLATION OF LAW FOR ANY PERSON,
 UNLESS THEY ARE ACTING UNDER THE DIRECTION
 OF A LICENSED PROFESSIONAL ENGINEER,
 TO ALTER THIS DOCUMENT.

DRAWN BY: CHECKED BY: APPROVED BY:
 MST --- ---
 RFDS REV #: 2 02/09/2022

CONSTRUCTION DOCUMENTS

SUBMITTALS		
REV	DATE	DESCRIPTION
A	06/14/2022	90% CD'S ISSUED FOR REVIEW

A&E PROJECT NUMBER
 SFSF000580A
 DISH Wireless L.L.C.
 PROJECT INFORMATION
 SFSF000580A
 100 FOUNTAIN GROVE PKWY
 SANTA ROSA, CA 95403

SHEET TITLE
 LEGEND AND ABBREVIATIONS

SHEET NUMBER
GN-1

SITE ACTIVITY REQUIREMENTS:

1. NOTICE TO PROCEED – NO WORK SHALL COMMENCE PRIOR TO CONTRACTOR RECEIVING A WRITTEN NOTICE TO PROCEED (NTP) AND THE ISSUANCE OF A PURCHASE ORDER. PRIOR TO ACCESSING/ENTERING THE SITE YOU MUST CONTACT THE DISH Wireless L.L.C. AND TOWER OWNER NOC & THE DISH Wireless L.L.C. AND TOWER OWNER CONSTRUCTION MANAGER.
2. "LOOK UP" – DISH Wireless L.L.C. AND TOWER OWNER SAFETY CLIMB REQUIREMENT:
THE INTEGRITY OF THE SAFETY CLIMB AND ALL COMPONENTS OF THE CLIMBING FACILITY SHALL BE CONSIDERED DURING ALL STAGES OF DESIGN, INSTALLATION, AND INSPECTION. TOWER MODIFICATION, MOUNT REINFORCEMENTS, AND/OR EQUIPMENT INSTALLATIONS SHALL NOT COMPROMISE THE INTEGRITY OR FUNCTIONAL USE OF THE SAFETY CLIMB OR ANY COMPONENTS OF THE CLIMBING FACILITY ON THE STRUCTURE. THIS SHALL INCLUDE, BUT NOT BE LIMITED TO: PINCHING OF THE WIRE ROPE, BENDING OF THE WIRE ROPE FROM ITS SUPPORTS, DIRECT CONTACT OR CLOSE PROXIMITY TO THE WIRE ROPE WHICH MAY CAUSE FRICTIONAL WEAR, IMPACT TO THE ANCHORAGE POINTS IN ANY WAY, OR TO IMPEDE/BLOCK ITS INTENDED USE. ANY COMPROMISED SAFETY CLIMB, INCLUDING EXISTING CONDITIONS MUST BE TAGGED OUT AND REPORTED TO YOUR DISH Wireless L.L.C. AND DISH Wireless L.L.C. AND TOWER OWNER POC OR CALL THE NOC TO GENERATE A SAFETY CLIMB MAINTENANCE AND CONTRACTOR NOTICE TICKET.
3. PRIOR TO THE START OF CONSTRUCTION, ALL REQUIRED JURISDICTIONAL PERMITS SHALL BE OBTAINED. THIS INCLUDES, BUT IS NOT LIMITED TO, BUILDING, ELECTRICAL, MECHANICAL, FIRE, FLOOD ZONE, ENVIRONMENTAL, AND ZONING. AFTER ONSITE ACTIVITIES AND CONSTRUCTION ARE COMPLETED, ALL REQUIRED PERMITS SHALL BE SATISFIED AND CLOSED OUT ACCORDING TO LOCAL JURISDICTIONAL REQUIREMENTS.
4. ALL CONSTRUCTION MEANS AND METHODS; INCLUDING BUT NOT LIMITED TO, ERECTION PLANS, RIGGING PLANS, CLIMBING PLANS, AND RESCUE PLANS SHALL BE THE RESPONSIBILITY OF THE GENERAL CONTRACTOR RESPONSIBLE FOR THE EXECUTION OF THE WORK CONTAINED HEREIN, AND SHALL MEET ANSI/ASSE A10.48 (LATEST EDITION); FEDERAL, STATE, AND LOCAL REGULATIONS; AND ANY APPLICABLE INDUSTRY CONSENSUS STANDARDS RELATED TO THE CONSTRUCTION ACTIVITIES BEING PERFORMED. ALL RIGGING PLANS SHALL ADHERE TO ANSI/ASSE A10.48 (LATEST EDITION) AND DISH Wireless L.L.C. AND TOWER OWNER STANDARDS, INCLUDING THE REQUIRED INVOLVEMENT OF A QUALIFIED ENGINEER FOR CLASS IV CONSTRUCTION, TO CERTIFY THE SUPPORTING STRUCTURE(S) IN ACCORDANCE WITH ANSI/TIA-322 (LATEST EDITION).
5. ALL SITE WORK TO COMPLY WITH DISH Wireless L.L.C. AND TOWER OWNER INSTALLATION STANDARDS FOR CONSTRUCTION ACTIVITIES ON DISH Wireless L.L.C. AND TOWER OWNER TOWER SITE AND LATEST VERSION OF ANSI/TIA-1019-A-2012 "STANDARD FOR INSTALLATION, ALTERATION, AND MAINTENANCE OF ANTENNA SUPPORTING STRUCTURES AND ANTENNAS."
6. IF THE SPECIFIED EQUIPMENT CAN NOT BE INSTALLED AS SHOWN ON THESE DRAWINGS, THE CONTRACTOR SHALL PROPOSE AN ALTERNATIVE INSTALLATION FOR APPROVAL BY DISH Wireless L.L.C. AND TOWER OWNER PRIOR TO PROCEEDING WITH ANY SUCH CHANGE OF INSTALLATION.
7. ALL MATERIALS FURNISHED AND INSTALLED SHALL BE IN STRICT ACCORDANCE WITH ALL APPLICABLE CODES, REGULATIONS AND ORDINANCES. CONTRACTOR SHALL ISSUE ALL APPROPRIATE NOTICES AND COMPLY WITH ALL LAWS, ORDINANCES, RULES, REGULATIONS AND LAWFUL ORDERS OF ANY PUBLIC AUTHORITY REGARDING THE PERFORMANCE OF THE WORK. ALL WORK CARRIED OUT SHALL COMPLY WITH ALL APPLICABLE MUNICIPAL AND UTILITY COMPANY SPECIFICATIONS AND LOCAL JURISDICTIONAL CODES, ORDINANCES AND APPLICABLE REGULATIONS.
8. THE CONTRACTOR SHALL INSTALL ALL EQUIPMENT AND MATERIALS IN ACCORDANCE WITH MANUFACTURER'S RECOMMENDATIONS UNLESS SPECIFICALLY STATED OTHERWISE.
9. THE CONTRACTOR SHALL CONTACT UTILITY LOCATING SERVICES INCLUDING PRIVATE LOCATES SERVICES PRIOR TO THE START OF CONSTRUCTION.
10. ALL EXISTING ACTIVE SEWER, WATER, GAS, ELECTRIC AND OTHER UTILITIES WHERE ENCOUNTERED IN THE WORK, SHALL BE PROTECTED AT ALL TIMES AND WHERE REQUIRED FOR THE PROPER EXECUTION OF THE WORK, SHALL BE RELOCATED AS DIRECTED BY CONTRACTOR. EXTREME CAUTION SHOULD BE USED BY THE CONTRACTOR WHEN EXCAVATING OR DRILLING PIERS AROUND OR NEAR UTILITIES. CONTRACTOR SHALL PROVIDE SAFETY TRAINING FOR THE WORKING CREW. THIS WILL INCLUDE BUT NOT BE LIMITED TO A) FALL PROTECTION B) CONFINED SPACE C) ELECTRICAL SAFETY D) TRENCHING AND EXCAVATION E) CONSTRUCTION SAFETY PROCEDURES.
11. ALL SITE WORK SHALL BE AS INDICATED ON THE STAMPED CONSTRUCTION DRAWINGS AND DISH PROJECT SPECIFICATIONS, LATEST APPROVED REVISION.
12. CONTRACTOR SHALL KEEP THE SITE FREE FROM ACCUMULATING WASTE MATERIAL, DEBRIS, AND TRASH AT THE COMPLETION OF THE WORK. IF NECESSARY, RUBBISH, STUMPS, DEBRIS, STICKS, STONES AND OTHER REFUSE SHALL BE REMOVED FROM THE SITE AND DISPOSED OF LEGALLY.
13. ALL EXISTING INACTIVE SEWER, WATER, GAS, ELECTRIC AND OTHER UTILITIES, WHICH INTERFERE WITH THE EXECUTION OF THE WORK, SHALL BE REMOVED AND/OR CAPPED, PLUGGED OR OTHERWISE DISCONTINUED AT POINTS WHICH WILL NOT INTERFERE WITH THE EXECUTION OF THE WORK, SUBJECT TO THE APPROVAL OF DISH Wireless L.L.C. AND TOWER OWNER, AND/OR LOCAL UTILITIES.
14. THE CONTRACTOR SHALL PROVIDE SITE SIGNAGE IN ACCORDANCE WITH THE TECHNICAL SPECIFICATION FOR SITE SIGNAGE REQUIRED BY LOCAL JURISDICTION AND SIGNAGE REQUIRED ON INDIVIDUAL PIECES OF EQUIPMENT, ROOMS, AND SHELTERS.
15. THE SITE SHALL BE GRADED TO CAUSE SURFACE WATER TO FLOW AWAY FROM THE CARRIER'S EQUIPMENT AND TOWER AREAS.
16. THE SUB GRADE SHALL BE COMPACTED AND BROUGHT TO A SMOOTH UNIFORM GRADE PRIOR TO FINISHED SURFACE APPLICATION.
17. THE AREAS OF THE OWNERS PROPERTY DISTURBED BY THE WORK AND NOT COVERED BY THE TOWER, EQUIPMENT OR DRIVEWAY, SHALL BE GRADED TO A UNIFORM SLOPE, AND STABILIZED TO PREVENT EROSION AS SPECIFIED ON THE CONSTRUCTION DRAWINGS AND/OR PROJECT SPECIFICATIONS.
18. CONTRACTOR SHALL MINIMIZE DISTURBANCE TO EXISTING SITE DURING CONSTRUCTION. EROSION CONTROL MEASURES, IF REQUIRED DURING CONSTRUCTION, SHALL BE IN CONFORMANCE WITH THE LOCAL GUIDELINES FOR EROSION AND SEDIMENT CONTROL.
19. THE CONTRACTOR SHALL PROTECT EXISTING IMPROVEMENTS, PAVEMENTS, CURBS, LANDSCAPING AND STRUCTURES. ANY DAMAGED PART SHALL BE REPAIRED AT CONTRACTOR'S EXPENSE TO THE SATISFACTION OF OWNER.
20. CONTRACTOR SHALL LEGALLY AND PROPERLY DISPOSE OF ALL SCRAP MATERIALS SUCH AS COAXIAL CABLES AND OTHER ITEMS REMOVED FROM THE EXISTING FACILITY. ANTENNAS AND RADIOS REMOVED SHALL BE RETURNED TO THE OWNER'S DESIGNATED LOCATION.
21. CONTRACTOR SHALL LEAVE PREMISES IN CLEAN CONDITION. TRASH AND DEBRIS SHOULD BE REMOVED FROM SITE ON A DAILY BASIS.
22. NO FILL OR EMBANKMENT MATERIAL SHALL BE PLACED ON FROZEN GROUND. FROZEN MATERIALS, SNOW OR ICE SHALL NOT BE PLACED IN ANY FILL OR EMBANKMENT.

GENERAL NOTES:

1. FOR THE PURPOSE OF CONSTRUCTION DRAWING, THE FOLLOWING DEFINITIONS SHALL APPLY:
CONTRACTOR: GENERAL CONTRACTOR RESPONSIBLE FOR CONSTRUCTION
CARRIER: DISH Wireless L.L.C.
TOWER OWNER: TOWER OWNER
2. THESE DRAWINGS HAVE BEEN PREPARED USING STANDARDS OF PROFESSIONAL CARE AND COMPLETENESS NORMALLY EXERCISED UNDER SIMILAR CIRCUMSTANCES BY REPUTABLE ENGINEERS IN THIS OR SIMILAR LOCALITIES. IT IS ASSUMED THAT THE WORK DEPICTED WILL BE PERFORMED BY AN EXPERIENCED CONTRACTOR AND/OR WORKPEOPLE WHO HAVE A WORKING KNOWLEDGE OF THE APPLICABLE CODE STANDARDS AND REQUIREMENTS AND OF INDUSTRY ACCEPTED STANDARD GOOD PRACTICE. AS NOT EVERY CONDITION OR ELEMENT IS (OR CAN BE) EXPLICITLY SHOWN ON THESE DRAWINGS, THE CONTRACTOR SHALL USE INDUSTRY ACCEPTED STANDARD GOOD PRACTICE FOR MISCELLANEOUS WORK NOT EXPLICITLY SHOWN.
3. THESE DRAWINGS REPRESENT THE FINISHED STRUCTURE. THEY DO NOT INDICATE THE MEANS OR METHODS OF CONSTRUCTION. THE CONTRACTOR SHALL BE SOLELY RESPONSIBLE FOR THE CONSTRUCTION MEANS, METHODS, TECHNIQUES, SEQUENCES, AND PROCEDURES. THE CONTRACTOR SHALL PROVIDE ALL MEASURES NECESSARY FOR PROTECTION OF LIFE AND PROPERTY DURING CONSTRUCTION. SUCH MEASURES SHALL INCLUDE, BUT NOT BE LIMITED TO, BRACING, FORMWORK, SHORING, ETC. SITE VISITS BY THE ENGINEER OR HIS REPRESENTATIVE WILL NOT INCLUDE INSPECTION OF THESE ITEMS AND IS FOR STRUCTURAL OBSERVATION OF THE FINISHED STRUCTURE ONLY.
4. NOTES AND DETAILS IN THE CONSTRUCTION DRAWINGS SHALL TAKE PRECEDENCE OVER GENERAL NOTES AND TYPICAL DETAILS. WHERE NO DETAILS ARE SHOWN, CONSTRUCTION SHALL CONFORM TO SIMILAR WORK ON THE PROJECT, AND/OR AS PROVIDED FOR IN THE CONTRACT DOCUMENTS. WHERE DISCREPANCIES OCCUR BETWEEN PLANS, DETAILS, GENERAL NOTES, AND SPECIFICATIONS, THE GREATER, MORE STRICT REQUIREMENTS, SHALL GOVERN. IF FURTHER CLARIFICATION IS REQUIRED CONTACT THE ENGINEER OF RECORD.
5. SUBSTANTIAL EFFORT HAS BEEN MADE TO PROVIDE ACCURATE DIMENSIONS AND MEASUREMENTS ON THE DRAWINGS TO ASSIST IN THE FABRICATION AND/OR PLACEMENT OF CONSTRUCTION ELEMENTS BUT IT IS THE SOLE RESPONSIBILITY OF THE CONTRACTOR TO FIELD VERIFY THE DIMENSIONS, MEASUREMENTS, AND/OR CLEARANCES SHOWN IN THE CONSTRUCTION DRAWINGS PRIOR TO FABRICATION OR CUTTING OF ANY NEW OR EXISTING CONSTRUCTION ELEMENTS. IF IT IS DETERMINED THAT THERE ARE DISCREPANCIES AND/OR CONFLICTS WITH THE CONSTRUCTION DRAWINGS THE ENGINEER OF RECORD IS TO BE NOTIFIED AS SOON AS POSSIBLE.
6. PRIOR TO THE SUBMISSION OF BIDS, THE BIDDING CONTRACTOR SHALL VISIT THE CELL SITE TO FAMILIARIZE WITH THE EXISTING CONDITIONS AND TO CONFIRM THAT THE WORK CAN BE ACCOMPLISHED AS SHOWN ON THE CONSTRUCTION DRAWINGS. ANY DISCREPANCY FOUND SHALL BE BROUGHT TO THE ATTENTION OF CARRIER POC AND TOWER OWNER.
7. ALL MATERIALS FURNISHED AND INSTALLED SHALL BE IN STRICT ACCORDANCE WITH ALL APPLICABLE CODES, REGULATIONS AND ORDINANCES. CONTRACTOR SHALL ISSUE ALL APPROPRIATE NOTICES AND COMPLY WITH ALL LAWS, ORDINANCES, RULES, REGULATIONS AND LAWFUL ORDERS OF ANY PUBLIC AUTHORITY REGARDING THE PERFORMANCE OF THE WORK. ALL WORK CARRIED OUT SHALL COMPLY WITH ALL APPLICABLE MUNICIPAL AND UTILITY COMPANY SPECIFICATIONS AND LOCAL JURISDICTIONAL CODES, ORDINANCES AND APPLICABLE REGULATIONS.
8. UNLESS NOTED OTHERWISE, THE WORK SHALL INCLUDE FURNISHING MATERIALS, EQUIPMENT, APPURTENANCES AND LABOR NECESSARY TO COMPLETE ALL INSTALLATIONS AS INDICATED ON THE DRAWINGS.
9. THE CONTRACTOR SHALL INSTALL ALL EQUIPMENT AND MATERIALS IN ACCORDANCE WITH MANUFACTURER'S RECOMMENDATIONS UNLESS SPECIFICALLY STATED OTHERWISE.
10. IF THE SPECIFIED EQUIPMENT CAN NOT BE INSTALLED AS SHOWN ON THESE DRAWINGS, THE CONTRACTOR SHALL PROPOSE AN ALTERNATIVE INSTALLATION FOR APPROVAL BY THE CARRIER AND TOWER OWNER PRIOR TO PROCEEDING WITH ANY SUCH CHANGE OF INSTALLATION.
11. CONTRACTOR IS TO PERFORM A SITE INVESTIGATION, BEFORE SUBMITTING BIDS, TO DETERMINE THE BEST ROUTING OF ALL CONDUITS FOR POWER, AND TELCO AND FOR GROUNDING CABLES AS SHOWN IN THE POWER, TELCO, AND GROUNDING PLAN DRAWINGS.
12. THE CONTRACTOR SHALL PROTECT EXISTING IMPROVEMENTS, PAVEMENTS, CURBS, LANDSCAPING AND STRUCTURES. ANY DAMAGED PART SHALL BE REPAIRED AT CONTRACTOR'S EXPENSE TO THE SATISFACTION OF DISH Wireless L.L.C. AND TOWER OWNER
13. CONTRACTOR SHALL LEGALLY AND PROPERLY DISPOSE OF ALL SCRAP MATERIALS SUCH AS COAXIAL CABLES AND OTHER ITEMS REMOVED FROM THE EXISTING FACILITY. ANTENNAS REMOVED SHALL BE RETURNED TO THE OWNER'S DESIGNATED LOCATION.
14. CONTRACTOR SHALL LEAVE PREMISES IN CLEAN CONDITION. TRASH AND DEBRIS SHOULD BE REMOVED FROM SITE ON A DAILY BASIS.



5701 SOUTH SANTA FE DRIVE
LITTLETON, CO 80120



2840 HOWE ROAD, SUITE E
MARTINEZ, CA 94553
www.TheCBRGroup.com

IT IS A VIOLATION OF LAW FOR ANY PERSON, UNLESS THEY ARE ACTING UNDER THE DIRECTION OF A LICENSED PROFESSIONAL ENGINEER, TO ALTER THIS DOCUMENT.

DRAWN BY: CHECKED BY: APPROVED BY:

MST --- ---

RFDS REV #: 2 02/09/2022

CONSTRUCTION DOCUMENTS

SUBMITTALS		
REV	DATE	DESCRIPTION
A	06/14/2022	90% CD'S ISSUED FOR REVIEW

A&E PROJECT NUMBER
SFSF000580A

DISH Wireless L.L.C.
PROJECT INFORMATION
SFSF000580A
100 FOUNTAIN GROVE PKWY
SANTA ROSA, CA 95403

SHEET TITLE
GENERAL NOTES

SHEET NUMBER
GN-2

CONCRETE, FOUNDATIONS, AND REINFORCING STEEL:

1. ALL CONCRETE WORK SHALL BE IN ACCORDANCE WITH THE ACI 301, ACI 318, ACI 336, ASTM A184, ASTM A185 AND THE DESIGN AND CONSTRUCTION SPECIFICATION FOR CAST-IN-PLACE CONCRETE.
2. UNLESS NOTED OTHERWISE, SOIL BEARING PRESSURE USED FOR DESIGN OF SLABS AND FOUNDATIONS IS ASSUMED TO BE 1000 psf.
3. ALL CONCRETE SHALL HAVE A MINIMUM COMPRESSIVE STRENGTH (f'c) OF 3000 psi AT 28 DAYS, UNLESS NOTED OTHERWISE. NO MORE THAN 90 MINUTES SHALL ELAPSE FROM BATCH TIME TO TIME OF PLACEMENT UNLESS APPROVED BY THE ENGINEER OF RECORD. TEMPERATURE OF CONCRETE SHALL NOT EXCEED 90°f AT TIME OF PLACEMENT.
4. CONCRETE EXPOSED TO FREEZE-THAW CYCLES SHALL CONTAIN AIR ENTRAINING ADMIXTURES. AMOUNT OF AIR ENTRAINMENT TO BE BASED ON SIZE OF AGGREGATE AND F3 CLASS EXPOSURE (VERY SEVERE). CEMENT USED TO BE TYPE II PORTLAND CEMENT WITH A MAXIMUM WATER-TO-CEMENT RATIO (W/C) OF 0.45.
5. ALL STEEL REINFORCING SHALL CONFORM TO ASTM A615. ALL WELDED WIRE FABRIC (WWF) SHALL CONFORM TO ASTM A185. ALL SPLICES SHALL BE CLASS "B" TENSION SPLICES, UNLESS NOTED OTHERWISE. ALL HOOKS SHALL BE STANDARD 90 DEGREE HOOKS, UNLESS NOTED OTHERWISE. YIELD STRENGTH (Fy) OF STANDARD DEFORMED BARS ARE AS FOLLOWS:
 - #4 BARS AND SMALLER 40 ksi
 - #5 BARS AND LARGER 60 ksi
6. THE FOLLOWING MINIMUM CONCRETE COVER SHALL BE PROVIDED FOR REINFORCING STEEL UNLESS SHOWN OTHERWISE ON DRAWINGS:
 - CONCRETE CAST AGAINST AND PERMANENTLY EXPOSED TO EARTH 3"
 - CONCRETE EXPOSED TO EARTH OR WEATHER:
 - #6 BARS AND LARGER 2"
 - #5 BARS AND SMALLER 1-1/2"
 - CONCRETE NOT EXPOSED TO EARTH OR WEATHER:
 - SLAB AND WALLS 3/4"
 - BEAMS AND COLUMNS 1-1/2"
7. A TOOLED EDGE OR A 3/4" CHAMFER SHALL BE PROVIDED AT ALL EXPOSED EDGES OF CONCRETE, UNLESS NOTED OTHERWISE, IN ACCORDANCE WITH ACI 301 SECTION 4.2.4.

ELECTRICAL INSTALLATION NOTES:

1. ALL ELECTRICAL WORK SHALL BE PERFORMED IN ACCORDANCE WITH THE PROJECT SPECIFICATIONS, NEC AND ALL APPLICABLE FEDERAL, STATE, AND LOCAL CODES/ORDINANCES.
2. CONDUIT ROUTINGS ARE SCHEMATIC. CONTRACTOR SHALL INSTALL CONDUITS SO THAT ACCESS TO EQUIPMENT IS NOT BLOCKED AND TRIP HAZARDS ARE ELIMINATED.
3. WIRING, RACEWAY AND SUPPORT METHODS AND MATERIALS SHALL COMPLY WITH THE REQUIREMENTS OF THE NEC.
4. ALL CIRCUITS SHALL BE SEGREGATED AND MAINTAIN MINIMUM CABLE SEPARATION AS REQUIRED BY THE NEC.
- 4.1. ALL EQUIPMENT SHALL BEAR THE UNDERWRITERS LABORATORIES LABEL OF APPROVAL, AND SHALL CONFORM TO REQUIREMENT OF THE NATIONAL ELECTRICAL CODE.
- 4.2. ALL OVERCURRENT DEVICES SHALL HAVE AN INTERRUPTING CURRENT RATING THAT SHALL BE GREATER THAN THE SHORT CIRCUIT CURRENT TO WHICH THEY ARE SUBJECTED, 22,000 AIC MINIMUM. VERIFY AVAILABLE SHORT CIRCUIT CURRENT DOES NOT EXCEED THE RATING OF ELECTRICAL EQUIPMENT IN ACCORDANCE WITH ARTICLE 110.24 NEC OR THE MOST CURRENT ADOPTED CODE PRE THE GOVERNING JURISDICTION.
5. EACH END OF EVERY POWER PHASE CONDUCTOR, GROUNDING CONDUCTOR, AND TELCO CONDUCTOR OR CABLE SHALL BE LABELED WITH COLOR-CODED INSULATION OR ELECTRICAL TAPE (3M BRAND, 1/2" PLASTIC ELECTRICAL TAPE WITH UV PROTECTION, OR EQUAL). THE IDENTIFICATION METHOD SHALL CONFORM WITH NEC AND OSHA.
6. ALL ELECTRICAL COMPONENTS SHALL BE CLEARLY LABELED WITH LAMICOID TAGS SHOWING THEIR RATED VOLTAGE, PHASE CONFIGURATION, WIRE CONFIGURATION, POWER OR AMPACITY RATING AND BRANCH CIRCUIT ID NUMBERS (i.e. PANEL BOARD AND CIRCUIT ID'S).
7. PANEL BOARDS (ID NUMBERS) SHALL BE CLEARLY LABELED WITH PLASTIC LABELS.
8. TIE WRAPS ARE NOT ALLOWED.
9. ALL POWER AND EQUIPMENT GROUND WIRING IN TUBING OR CONDUIT SHALL BE SINGLE COPPER CONDUCTOR (#14 OR LARGER) WITH TYPE THHW, THWN, THWN-2, XHHW, XHHW-2, THW, THW-2, RHW, OR RHW-2 INSULATION UNLESS OTHERWISE SPECIFIED.
10. SUPPLEMENTAL EQUIPMENT GROUND WIRING LOCATED INDOORS SHALL BE SINGLE COPPER CONDUCTOR (#6 OR LARGER) WITH TYPE THHW, THWN, THWN-2, XHHW, XHHW-2, THW, THW-2, RHW, OR RHW-2 INSULATION UNLESS OTHERWISE SPECIFIED.
11. POWER AND CONTROL WIRING IN FLEXIBLE CORD SHALL BE MULTI-CONDUCTOR, TYPE SOOW CORD (#14 OR LARGER) UNLESS OTHERWISE SPECIFIED.
12. POWER AND CONTROL WIRING FOR USE IN CABLE TRAY SHALL BE MULTI-CONDUCTOR, TYPE TC CABLE (#14 OR LARGER), WITH TYPE THHW, THWN, THWN-2, XHHW, XHHW-2, THW, THW-2, RHW, OR RHW-2 INSULATION UNLESS OTHERWISE SPECIFIED.
13. ALL POWER AND GROUNDING CONNECTIONS SHALL BE CRIMP-STYLE, COMPRESSION WIRE LUGS AND WIRE NUTS BY THOMAS AND BETTS (OR EQUAL). LUGS AND WIRE NUTS SHALL BE RATED FOR OPERATION NOT LESS THAN 75° C (90° C IF AVAILABLE).
14. RACEWAY AND CABLE TRAY SHALL BE LISTED OR LABELED FOR ELECTRICAL USE IN ACCORDANCE WITH NEMA, UL, ANSI/IEEE AND NEC.
15. ELECTRICAL METALLIC TUBING (EMT), INTERMEDIATE METAL CONDUIT (IMC), OR RIGID METAL CONDUIT (RMC) SHALL BE USED FOR EXPOSED INDOOR LOCATIONS.

16. ELECTRICAL METALLIC TUBING (EMT) OR METAL-CLAD CABLE (MC) SHALL BE USED FOR CONCEALED INDOOR LOCATIONS.
17. SCHEDULE 40 PVC UNDERGROUND ON STRAIGHTS AND SCHEDULE 80 PVC FOR ALL ELBOWS/90s AND ALL APPROVED ABOVE GRADE PVC CONDUIT.
18. LIQUID-TIGHT FLEXIBLE METALLIC CONDUIT (LIQUID-TITE FLEX) SHALL BE USED INDOORS AND OUTDOORS, WHERE VIBRATION OCCURS OR FLEXIBILITY IS NEEDED.
19. CONDUIT AND TUBING FITTINGS SHALL BE THREADED OR COMPRESSION-TYPE AND APPROVED FOR THE LOCATION USED. SET SCREW FITTINGS ARE NOT ACCEPTABLE.
20. CABINETS, BOXES AND WIRE WAYS SHALL BE LABELED FOR ELECTRICAL USE IN ACCORDANCE WITH NEMA, UL, ANSI/IEEE AND THE NEC.
21. WIREWAYS SHALL BE METAL WITH AN ENAMEL FINISH AND INCLUDE A HINGED COVER, DESIGNED TO SWING OPEN DOWNWARDS (WIREMOLD SPECMATE WIREWAY).
22. SLOTTED WIRING DUCT SHALL BE PVC AND INCLUDE COVER (PANDUIT TYPE E OR EQUAL).
23. CONDUITS SHALL BE FASTENED SECURELY IN PLACE WITH APPROVED NON-PERFORATED STRAPS AND HANGERS. EXPLOSIVE DEVICES (i.e. POWDER-ACTUATED) FOR ATTACHING HANGERS TO STRUCTURE WILL NOT BE PERMITTED. CLOSELY FOLLOW THE LINES OF THE STRUCTURE, MAINTAIN CLOSE PROXIMITY TO THE STRUCTURE AND KEEP CONDUITS IN TIGHT ENVELOPES. CHANGES IN DIRECTION TO ROUTE AROUND OBSTACLES SHALL BE MADE WITH CONDUIT OUTLET BODIES. CONDUIT SHALL BE INSTALLED IN A NEAT AND WORKMANLIKE MANNER. PARALLEL AND PERPENDICULAR TO STRUCTURE WALL AND CEILING LINES. ALL CONDUIT SHALL BE FISHED TO CLEAR OBSTRUCTIONS. ENDS OF CONDUITS SHALL BE TEMPORARILY CAPPED FLUSH TO FINISH GRADE TO PREVENT CONCRETE, PLASTER OR DIRT FROM ENTERING. CONDUITS SHALL BE RIGIDLY CLAMPED TO BOXES BY GALVANIZED MALLEABLE IRON BUSHING ON INSIDE AND GALVANIZED MALLEABLE IRON LOCKNUT ON OUTSIDE AND INSIDE.
24. EQUIPMENT CABINETS, TERMINAL BOXES, JUNCTION BOXES AND PULL BOXES SHALL BE GALVANIZED OR EPOXY-COATED SHEET STEEL. SHALL MEET OR EXCEED UL 50 AND BE RATED NEMA 1 (OR BETTER) FOR INTERIOR LOCATIONS AND NEMA 3 (OR BETTER) FOR EXTERIOR LOCATIONS.
25. METAL RECEPTACLE, SWITCH AND DEVICE BOXES SHALL BE GALVANIZED, EPOXY-COATED OR NON-CORRODING; SHALL MEET OR EXCEED UL 514A AND NEMA OS 1 AND BE RATED NEMA 1 (OR BETTER) FOR INTERIOR LOCATIONS AND WEATHER PROTECTED (WP OR BETTER) FOR EXTERIOR LOCATIONS.
26. NONMETALLIC RECEPTACLE, SWITCH AND DEVICE BOXES SHALL MEET OR EXCEED NEMA OS 2 (NEWEST REVISION) AND BE RATED NEMA 1 (OR BETTER) FOR INTERIOR LOCATIONS AND WEATHER PROTECTED (WP OR BETTER) FOR EXTERIOR LOCATIONS.
27. THE CONTRACTOR SHALL NOTIFY AND OBTAIN NECESSARY AUTHORIZATION FROM THE CARRIER AND/OR DISH Wireless L.L.C. AND TOWER OWNER BEFORE COMMENCING WORK ON THE AC POWER DISTRIBUTION PANELS.
28. THE CONTRACTOR SHALL PROVIDE NECESSARY TAGGING ON THE BREAKERS, CABLES AND DISTRIBUTION PANELS IN ACCORDANCE WITH THE APPLICABLE CODES AND STANDARDS TO SAFEGUARD LIFE AND PROPERTY.
29. INSTALL LAMICOID LABEL ON THE METER CENTER TO SHOW "DISH Wireless L.L.C.".
30. ALL EMPTY/SPARE CONDUITS THAT ARE INSTALLED ARE TO HAVE A METERED MULE TAPE PULL CORD INSTALLED.



5701 SOUTH SANTA FE DRIVE
LITTLETON, CO 80120



2840 HOWE ROAD, SUITE E
MARTINEZ, CA 94553
www.TheCBRGroup.com

IT IS A VIOLATION OF LAW FOR ANY PERSON, UNLESS THEY ARE ACTING UNDER THE DIRECTION OF A LICENSED PROFESSIONAL ENGINEER, TO ALTER THIS DOCUMENT.

DRAWN BY: CHECKED BY: APPROVED BY:

MST --- ---

RFDS REV #: 2 02/09/2022

CONSTRUCTION DOCUMENTS

SUBMITTALS		
REV	DATE	DESCRIPTION
A	06/14/2022	90% CD'S ISSUED FOR REVIEW

A&E PROJECT NUMBER
SFSF000580A

DISH Wireless L.L.C.
PROJECT INFORMATION
SFSF000580A
100 FOUNTAIN GROVE PKWY
SANTA ROSA, CA 95403

SHEET TITLE
GENERAL NOTES

SHEET NUMBER
GN-3

GROUNDING NOTES:

1. ALL GROUND ELECTRODE SYSTEMS (INCLUDING TELECOMMUNICATION, RADIO, LIGHTNING PROTECTION AND AC POWER GES'S) SHALL BE BONDED TOGETHER AT OR BELOW GRADE, BY TWO OR MORE COPPER BONDING CONDUCTORS IN ACCORDANCE WITH THE NEC.
2. THE CONTRACTOR SHALL PERFORM IEEE FALL-OF-POTENTIAL RESISTANCE TO EARTH TESTING (PER IEEE 1100 AND 81) FOR GROUND ELECTRODE SYSTEMS, THE CONTRACTOR SHALL FURNISH AND INSTALL SUPPLEMENTAL GROUND ELECTRODES AS NEEDED TO ACHIEVE A TEST RESULT OF 5 OHMS OR LESS.
3. THE CONTRACTOR IS RESPONSIBLE FOR PROPERLY SEQUENCING GROUNDING AND UNDERGROUND CONDUIT INSTALLATION AS TO PREVENT ANY LOSS OF CONTINUITY IN THE GROUNDING SYSTEM OR DAMAGE TO THE CONDUIT AND PROVIDE TESTING RESULTS.
4. METAL CONDUIT AND TRAY SHALL BE GROUNDED AND MADE ELECTRICALLY CONTINUOUS WITH LISTED BONDING FITTINGS OR BY BONDING ACROSS THE DISCONTINUITY WITH #6 COPPER WIRE UL APPROVED GROUNDING TYPE CONDUIT CLAMPS.
5. METAL RACEWAY SHALL NOT BE USED AS THE NEC REQUIRED EQUIPMENT GROUND CONDUCTOR. STRANDED COPPER CONDUCTORS WITH GREEN INSULATION, SIZED IN ACCORDANCE WITH THE NEC, SHALL BE FURNISHED AND INSTALLED WITH THE POWER CIRCUITS TO BTS EQUIPMENT.
6. EACH CABINET FRAME SHALL BE DIRECTLY CONNECTED TO THE MASTER GROUND BAR WITH GREEN INSULATED SUPPLEMENTAL EQUIPMENT GROUND WIRES, #6 STRANDED COPPER OR LARGER FOR INDOOR BTS; #2 BARE SOLID TINNED COPPER FOR OUTDOOR BTS.
7. CONNECTIONS TO THE GROUND BUS SHALL NOT BE DOUBLED UP OR STACKED BACK TO BACK CONNECTIONS ON OPPOSITE SIDE OF THE GROUND BUS ARE PERMITTED.
8. ALL EXTERIOR GROUND CONDUCTORS BETWEEN EQUIPMENT/GROUND BARS AND THE GROUND RING SHALL BE #2 SOLID TINNED COPPER UNLESS OTHERWISE INDICATED.
9. ALUMINUM CONDUCTOR OR COPPER CLAD STEEL CONDUCTOR SHALL NOT BE USED FOR GROUNDING CONNECTIONS.
10. USE OF 90° BENDS IN THE PROTECTION GROUNDING CONDUCTORS SHALL BE AVOIDED WHEN 45° BENDS CAN BE ADEQUATELY SUPPORTED.
11. EXOTHERMIC WELDS SHALL BE USED FOR ALL GROUNDING CONNECTIONS BELOW GRADE.
12. ALL GROUND CONNECTIONS ABOVE GRADE (INTERIOR AND EXTERIOR) SHALL BE FORMED USING HIGH PRESS CRIMPS.
13. COMPRESSION GROUND CONNECTIONS MAY BE REPLACED BY EXOTHERMIC WELD CONNECTIONS.
14. ICE BRIDGE BONDING CONDUCTORS SHALL BE EXOTHERMICALLY BONDED OR BOLTED TO THE BRIDGE AND THE TOWER GROUND BAR.
15. APPROVED ANTIOXIDANT COATINGS (i.e. CONDUCTIVE GEL OR PASTE) SHALL BE USED ON ALL COMPRESSION AND BOLTED GROUND CONNECTIONS.
16. ALL EXTERIOR GROUND CONNECTIONS SHALL BE COATED WITH A CORROSION RESISTANT MATERIAL.
17. MISCELLANEOUS ELECTRICAL AND NON-ELECTRICAL METAL BOXES, FRAMES AND SUPPORTS SHALL BE BONDED TO THE GROUND RING, IN ACCORDANCE WITH THE NEC.
18. BOND ALL METALLIC OBJECTS WITHIN 6 ft OF MAIN GROUND RING WITH (1) #2 BARE SOLID TINNED COPPER GROUND CONDUCTOR.
19. GROUND CONDUCTORS USED FOR THE FACILITY GROUNDING AND LIGHTNING PROTECTION SYSTEMS SHALL NOT BE ROUTED THROUGH METALLIC OBJECTS THAT FORM A RING AROUND THE CONDUCTOR, SUCH AS METALLIC CONDUITS, METAL SUPPORT CLIPS OR SLEEVES THROUGH WALLS OR FLOORS. WHEN IT IS REQUIRED TO BE HOUSED IN CONDUIT TO MEET CODE REQUIREMENTS OR LOCAL CONDITIONS, NON-METALLIC MATERIAL SUCH AS PVC CONDUIT SHALL BE USED. WHERE USE OF METAL CONDUIT IS UNAVOIDABLE (i.e., NONMETALLIC CONDUIT PROHIBITED BY LOCAL CODE) THE GROUND CONDUCTOR SHALL BE BONDED TO EACH END OF THE METAL CONDUIT.
20. ALL GROUNDS THAT TRANSITION FROM BELOW GRADE TO ABOVE GRADE MUST BE #2 BARE SOLID TINNED COPPER IN 3/4" NON-METALLIC, FLEXIBLE CONDUIT FROM 24" BELOW GRADE TO WITHIN 3" TO 6" OF CAD-WELD TERMINATION POINT. THE EXPOSED END OF THE CONDUIT MUST BE SEALED WITH SILICONE CAULK. (ADD TRANSITIONING GROUND STANDARD DETAIL AS WELL).
21. BUILDINGS WHERE THE MAIN GROUNDING CONDUCTORS ARE REQUIRED TO BE ROUTED TO GRADE, THE CONTRACTOR SHALL ROUTE TWO GROUNDING CONDUCTORS FROM THE ROOFTOP, TOWERS, AND WATER TOWERS GROUNDING RING, TO THE EXISTING GROUNDING SYSTEM, THE GROUNDING CONDUCTORS SHALL NOT BE SMALLER THAN 2/0 COPPER. ROOFTOP GROUNDING RING SHALL BE BONDED TO THE EXISTING GROUNDING SYSTEM, THE BUILDING STEEL COLUMNS, LIGHTNING PROTECTION SYSTEM, AND BUILDING MAIN WATER LINE (FERROUS OR NONFERROUS METAL PIPING ONLY). DO NOT ATTACH GROUNDING TO FIRE SPRINKLER SYSTEM PIPES.



5701 SOUTH SANTA FE DRIVE
LITTLETON, CO 80120



2840 HOWE ROAD, SUITE E
MARTINEZ, CA 94553
www.TheCBRGroup.com

IT IS A VIOLATION OF LAW FOR ANY PERSON, UNLESS THEY ARE ACTING UNDER THE DIRECTION OF A LICENSED PROFESSIONAL ENGINEER, TO ALTER THIS DOCUMENT.

DRAWN BY: CHECKED BY: APPROVED BY:

MST --- ---

RFDS REV #: 2 02/09/2022

CONSTRUCTION DOCUMENTS

SUBMITTALS		
REV	DATE	DESCRIPTION
A	06/14/2022	90% CD'S ISSUED FOR REVIEW

A&E PROJECT NUMBER
SFSF000580A

DISH Wireless L.L.C.
PROJECT INFORMATION
SFSF000580A
100 FOUNTAIN GROVE PKWY
SANTA ROSA, CA 95403

SHEET TITLE
GENERAL NOTES

SHEET NUMBER
GN-4